

INDEX OF PLANS

SHEET No.	DESCRIPTION
1	TITLE AND LOCATION MAP
2-5	CONSTRUCTION DETAILS
6	CONSTRUCTION AREA SIGNS
7	PAVEMENT DELINEATION QUANTITIES
8	SUMMARY OF QUANTITIES
9-12	ELECTRICAL PLANS
13-25	REVISED STANDARD PLANS



THE STANDARD PLANS LIST APPLICABLE TO THIS CONTRACT IS INCLUDED IN THE NOTICE TO BIDDERS AND SPECIAL PROVISIONS BOOK.

STATE OF CALIFORNIA
DEPARTMENT OF TRANSPORTATION

ACHSNH-000C(394)

PROJECT PLANS FOR CONSTRUCTION ON
STATE HIGHWAY
IN EL DORADO, SACRAMENTO AND YOLO COUNTIES
AT
VARIOUS LOCATIONS

TO BE SUPPLEMENTED BY STANDARD PLANS DATED 2010

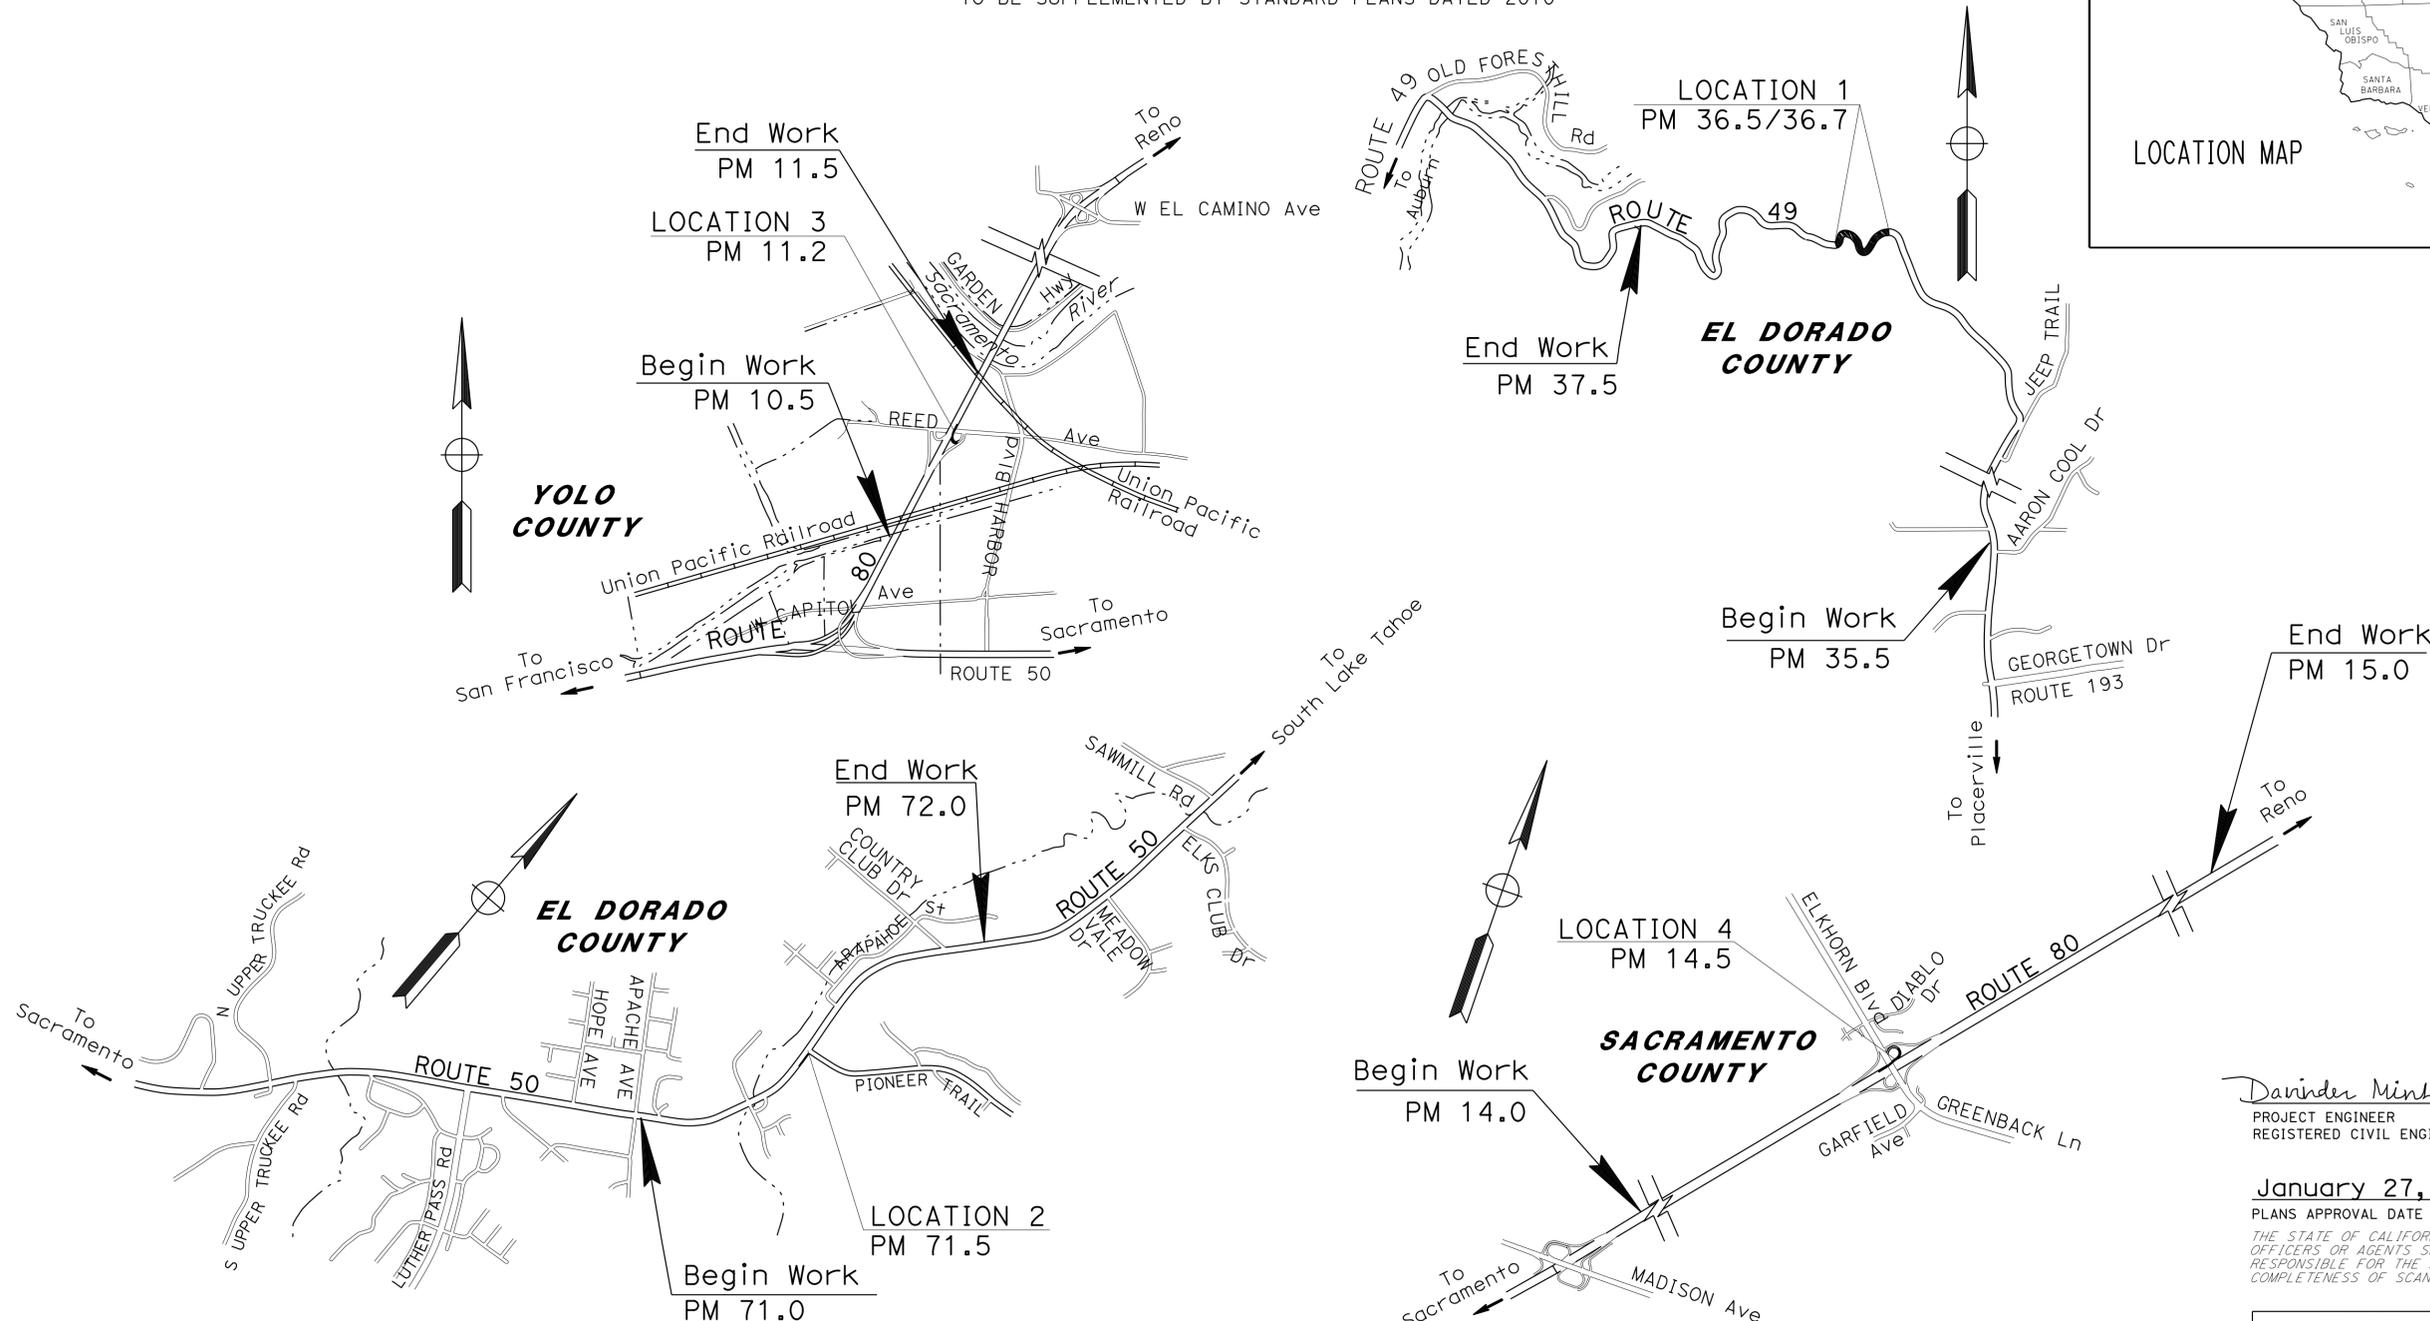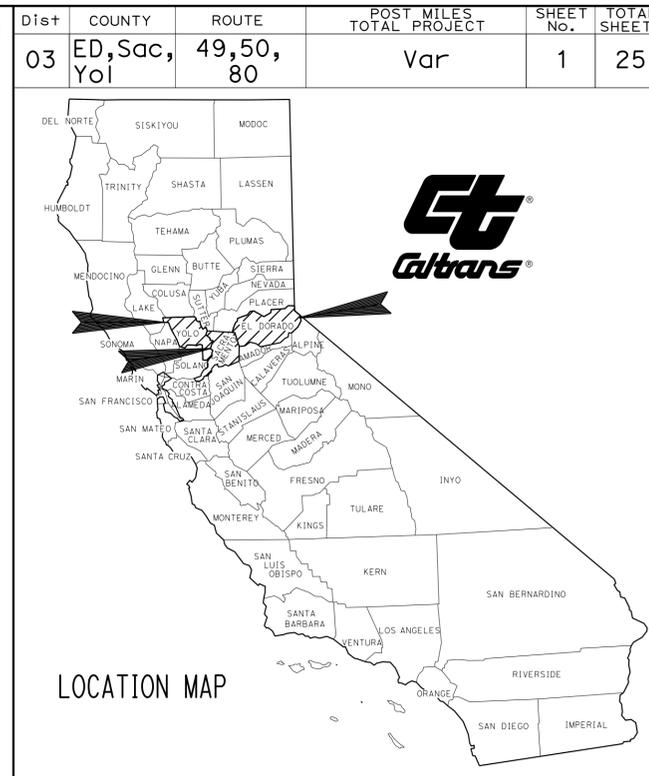

PROJECT MANAGER
NADARAJAH SUTHAHAR

DESIGN MANAGER
MIKE HAGEN

DAVINDER MINHAS 1-27-15
PROJECT ENGINEER DATE
REGISTERED CIVIL ENGINEER

January 27, 2015
PLANS APPROVAL DATE

THE STATE OF CALIFORNIA OR ITS OFFICERS OR AGENTS SHALL NOT BE RESPONSIBLE FOR THE ACCURACY OR COMPLETENESS OF SCANNED COPIES OF THIS PLAN SHEET.

CONTRACT No. **00-4F3904**

PROJECT ID **0314000157**

Dist	COUNTY	ROUTE	POST MILES TOTAL PROJECT	SHEET No.	TOTAL SHEETS
03	ED, Sac, Yoi	49, 50 80	Var	2	25

Davinder Minhas 1-27-15
 REGISTERED CIVIL ENGINEER DATE
 1-27-15
 PLANS APPROVAL DATE
 THE STATE OF CALIFORNIA OR ITS OFFICERS OR AGENTS SHALL NOT BE RESPONSIBLE FOR THE ACCURACY OR COMPLETENESS OF SCANNED COPIES OF THIS PLAN SHEET.

REGISTERED PROFESSIONAL ENGINEER
 DAVINDER MINHAS
 No. 70022
 Exp. 09/30/16
 CIVIL
 STATE OF CALIFORNIA

NOTES:



1. ALL STRIPING, PAVEMENT MARKINGS, AND PAVEMENT MARKERS WITHIN THE LIMITS OF HIGH FRICTION SURFACE TREATMENT APPLICATION, TO BE REMOVED AND REPLACED.
2. FOR REMOVAL QUANTITIES OF PAVEMENT STRIPING AND MARKING, SEE PAVEMENT DELINEATION QUANTITIES SHEET.
3. FOR QUANTITIES OF PAVEMENT DELINEATION, SEE PAVEMENT DELINEATION QUANTITIES SHEET.

ABBREVIATION:

HFST(PR) HIGH FRICTION SURFACE TREATMENT (POLYMER RESIN)

LEGEND:

- LIMITS OF HFST(PR)
- LIMITS OF HFST(PR) - 2 LAYERS
- LIMITS OF HFST(PR)
- LIMITS OF REPLACE AC SURFACING - 0.25' HMA (TYPE A)
- LIMITS OF HFST(PR)
- LIMITS OF PREPARE CONCRETE BRIDGE DECK SURFACE

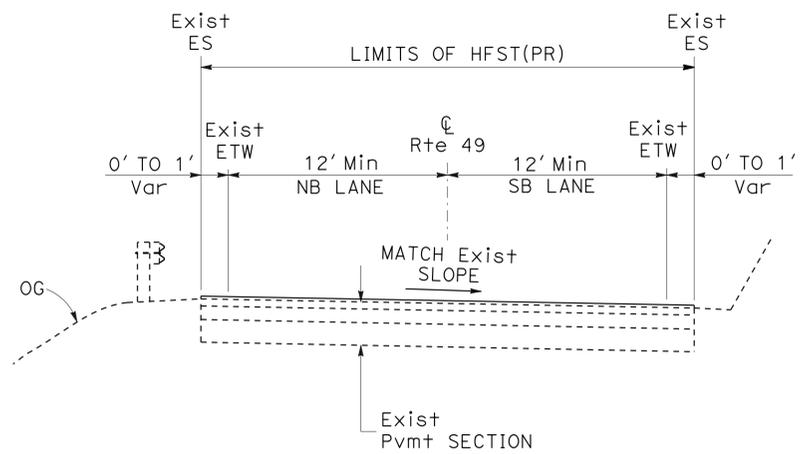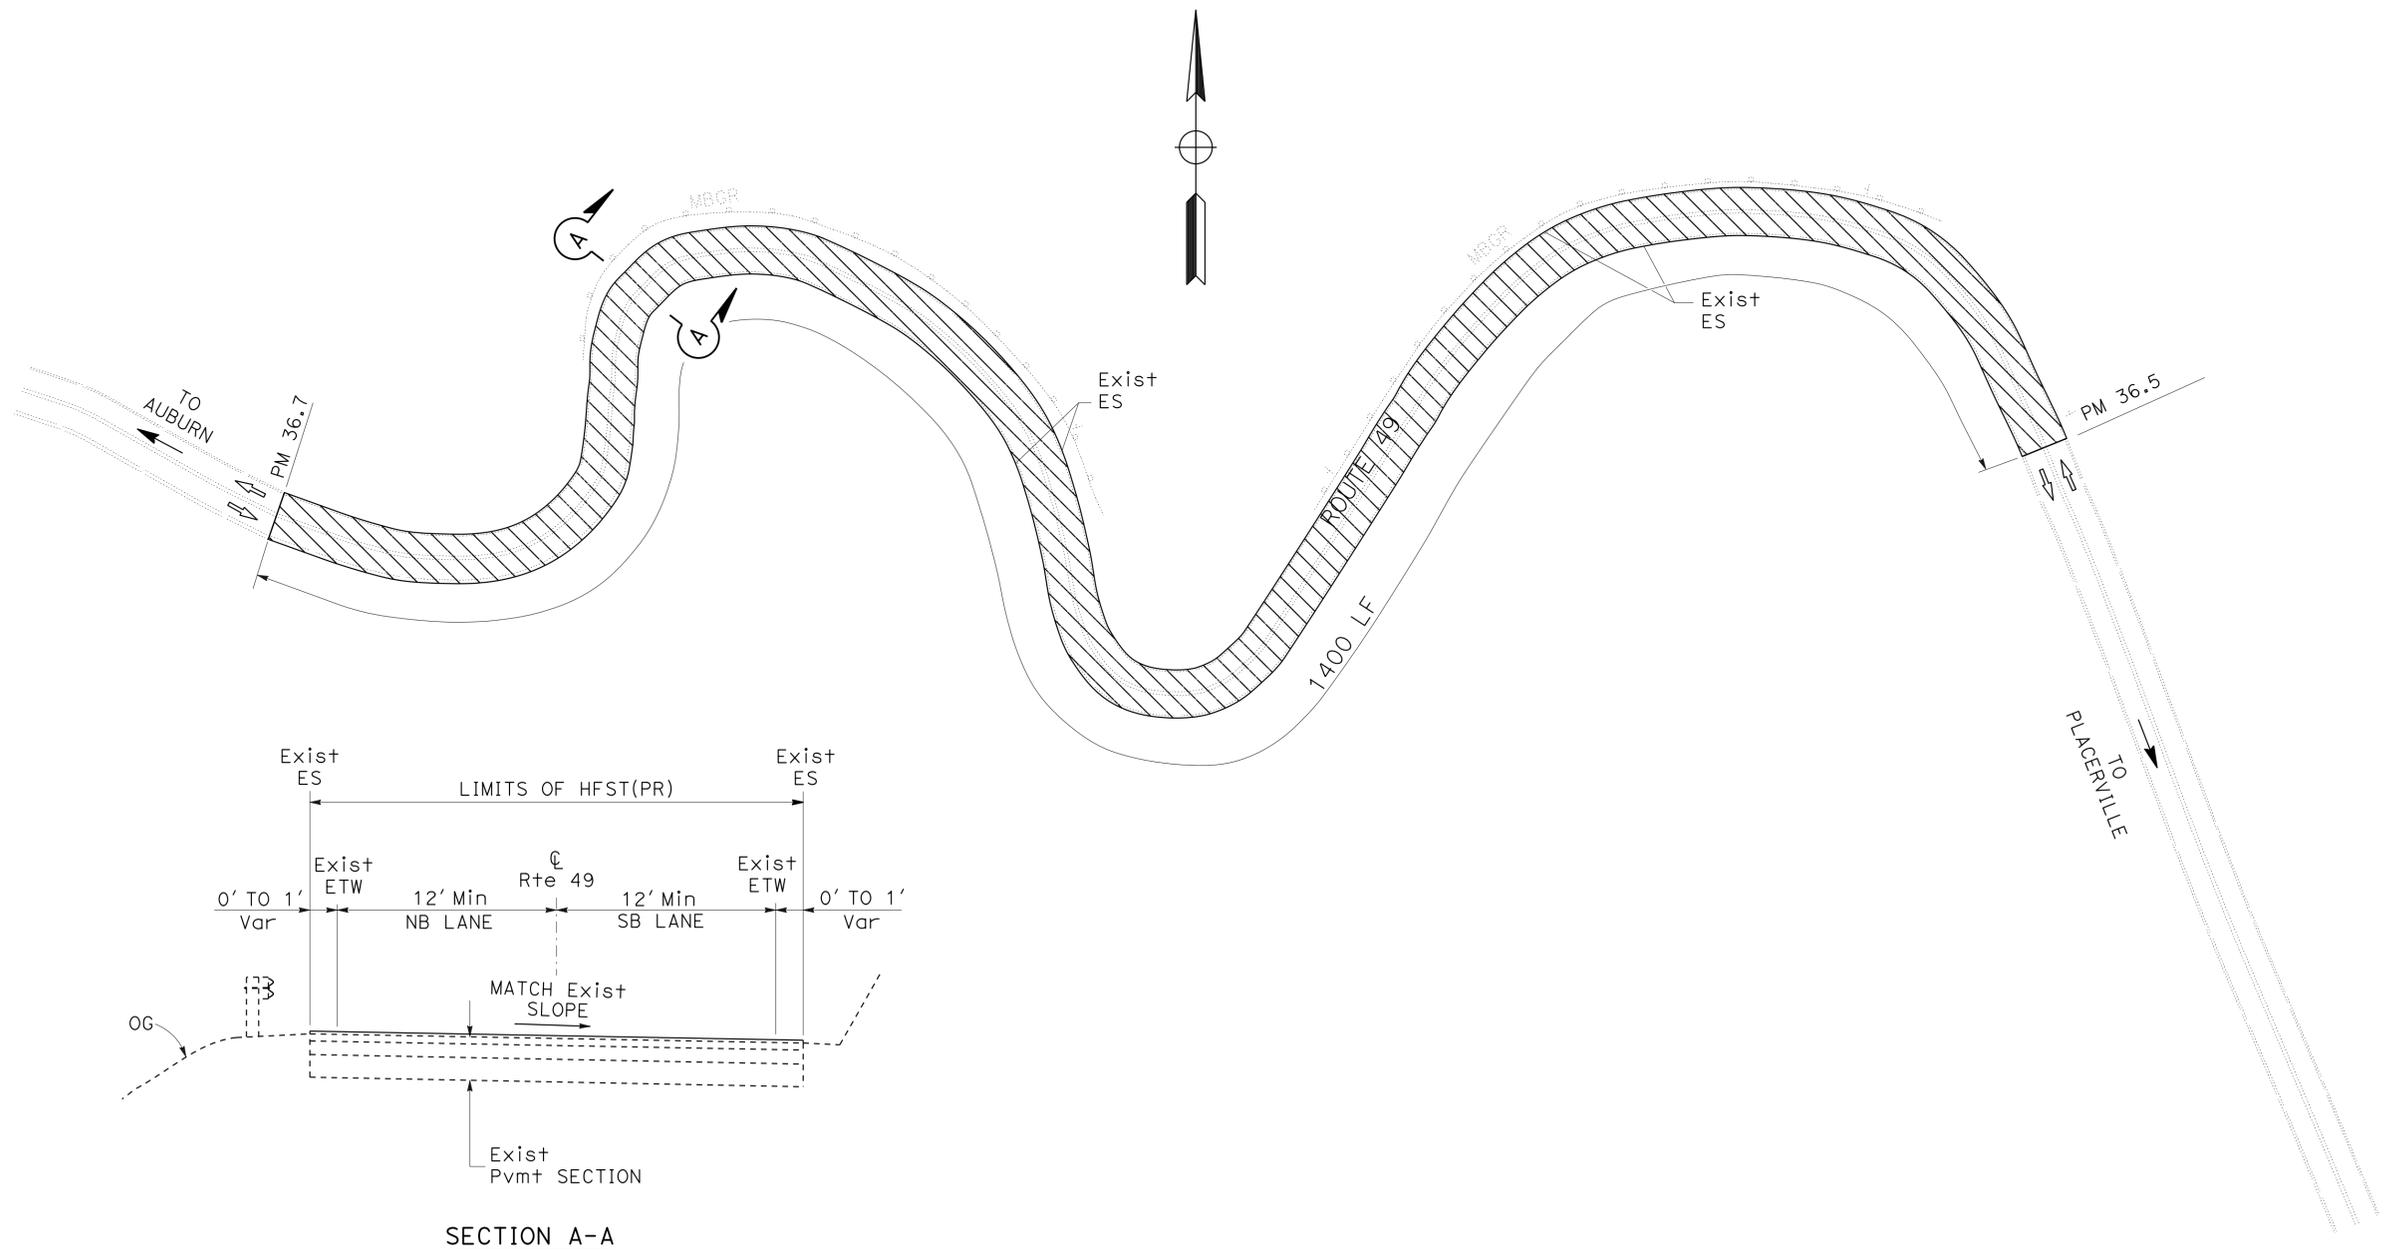

SECTION A-A

LOCATION 1
ED-49 PM 36.5/36.7

CONSTRUCTION DETAILS
 NO SCALE

C-1

STATE OF CALIFORNIA - DEPARTMENT OF TRANSPORTATION	DAVIDER MINHAS	REVISOR	DATE
TRAFFIC SAFETY	DENNIS CORCORAN	REVISOR	DATE
FUNCTIONAL SUPERVISOR	CHECKED BY	DESIGNED BY	DATE
MIKE HAGEN			




STATE OF CALIFORNIA - DEPARTMENT OF TRANSPORTATION	FUNCTIONAL SUPERVISOR	CALCULATED/DESIGNED BY	REVISOR	DATE
Caltrans TRAFFIC SAFETY	MIKE HAGEN	CHECKED BY	DAVINDER MINHAS	1-27-15
			DENNIS CORCORAN	

Dist	COUNTY	ROUTE	POST MILES TOTAL PROJECT	SHEET No.	TOTAL SHEETS
03	ED, Sac, Yoi	49, 50 80	Var	3	25

Davinder Minhas 1-27-15
 REGISTERED CIVIL ENGINEER DATE
 1-27-15
 PLANS APPROVAL DATE

REGISTERED PROFESSIONAL ENGINEER
 DAVINDER MINHAS
 No. 70022
 Exp. 09/30/16
 CIVIL
 STATE OF CALIFORNIA

THE STATE OF CALIFORNIA OR ITS OFFICERS OR AGENTS SHALL NOT BE RESPONSIBLE FOR THE ACCURACY OR COMPLETENESS OF SCANNED COPIES OF THIS PLAN SHEET.

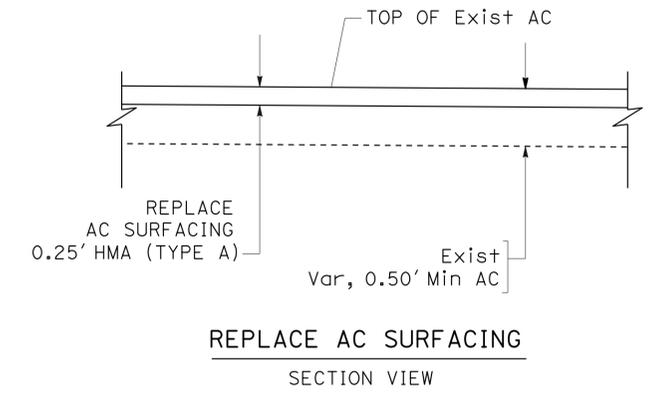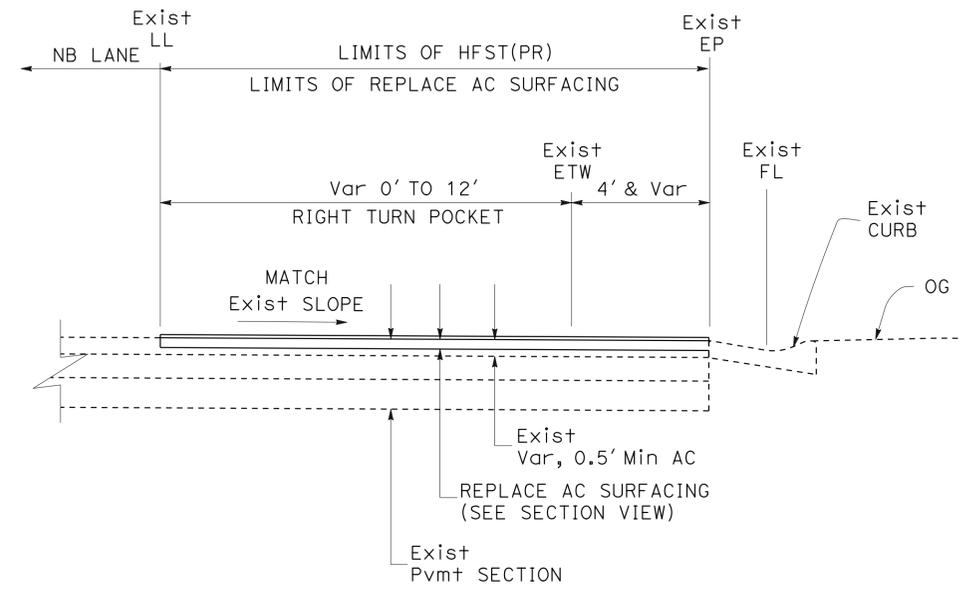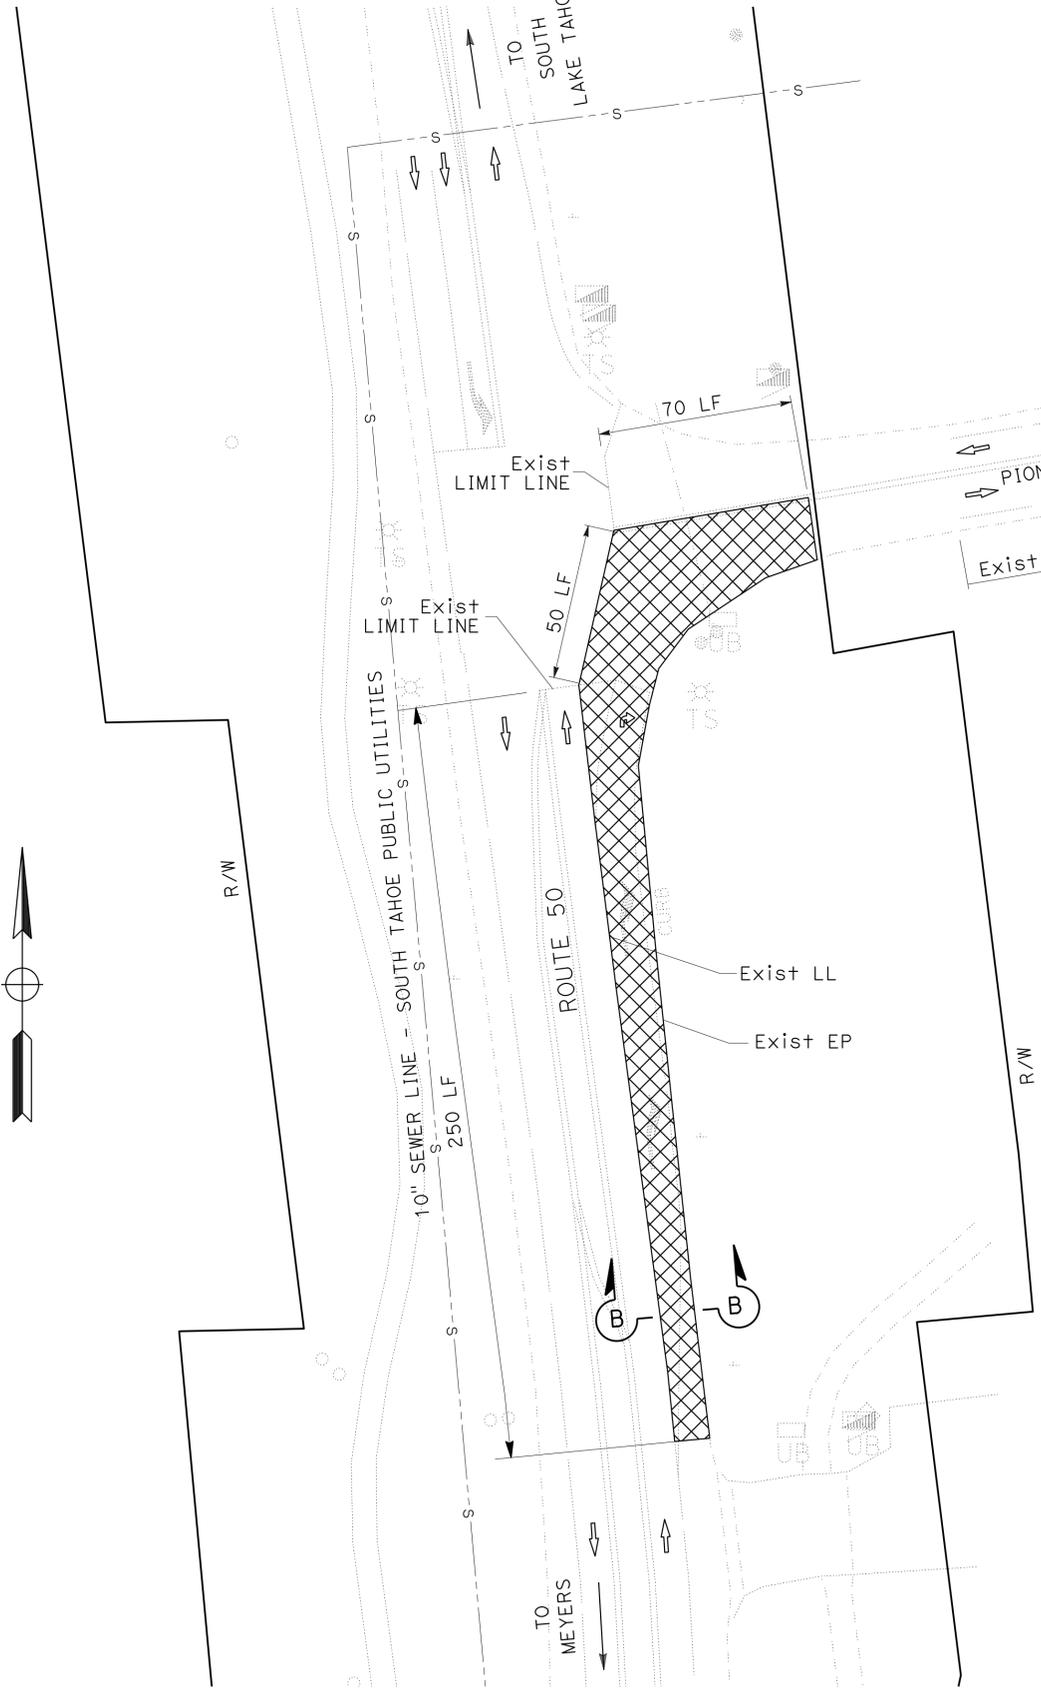

LOCATION 2
ED-50 PM 71.5
PIONEER TRAIL (RIGHT TURN POCKET)

CONSTRUCTION DETAILS
 NO SCALE
C-2

STATE OF CALIFORNIA - DEPARTMENT OF TRANSPORTATION
Caltrans TRAFFIC SAFETY

FUNCTIONAL SUPERVISOR
 MIKE HAGEN


CALCULATED/DESIGNED BY
 CHECKED BY

DAVINDER MINHAS
 DENNIS CORCORAN

REVISED BY
 DATE REVISED

NOTES (THIS SHEET ONLY):

1. HFST(PR) TO BE TERMINATED 1' AWAY FROM THE BRIDGE BARRIER RAILING.
2. PREPARE CONCRETE BRIDGE DECK SURFACE BEFORE THE APPLICATION OF HFST(PR) WITHIN THE LIMITS OF THE STRUCTURE.

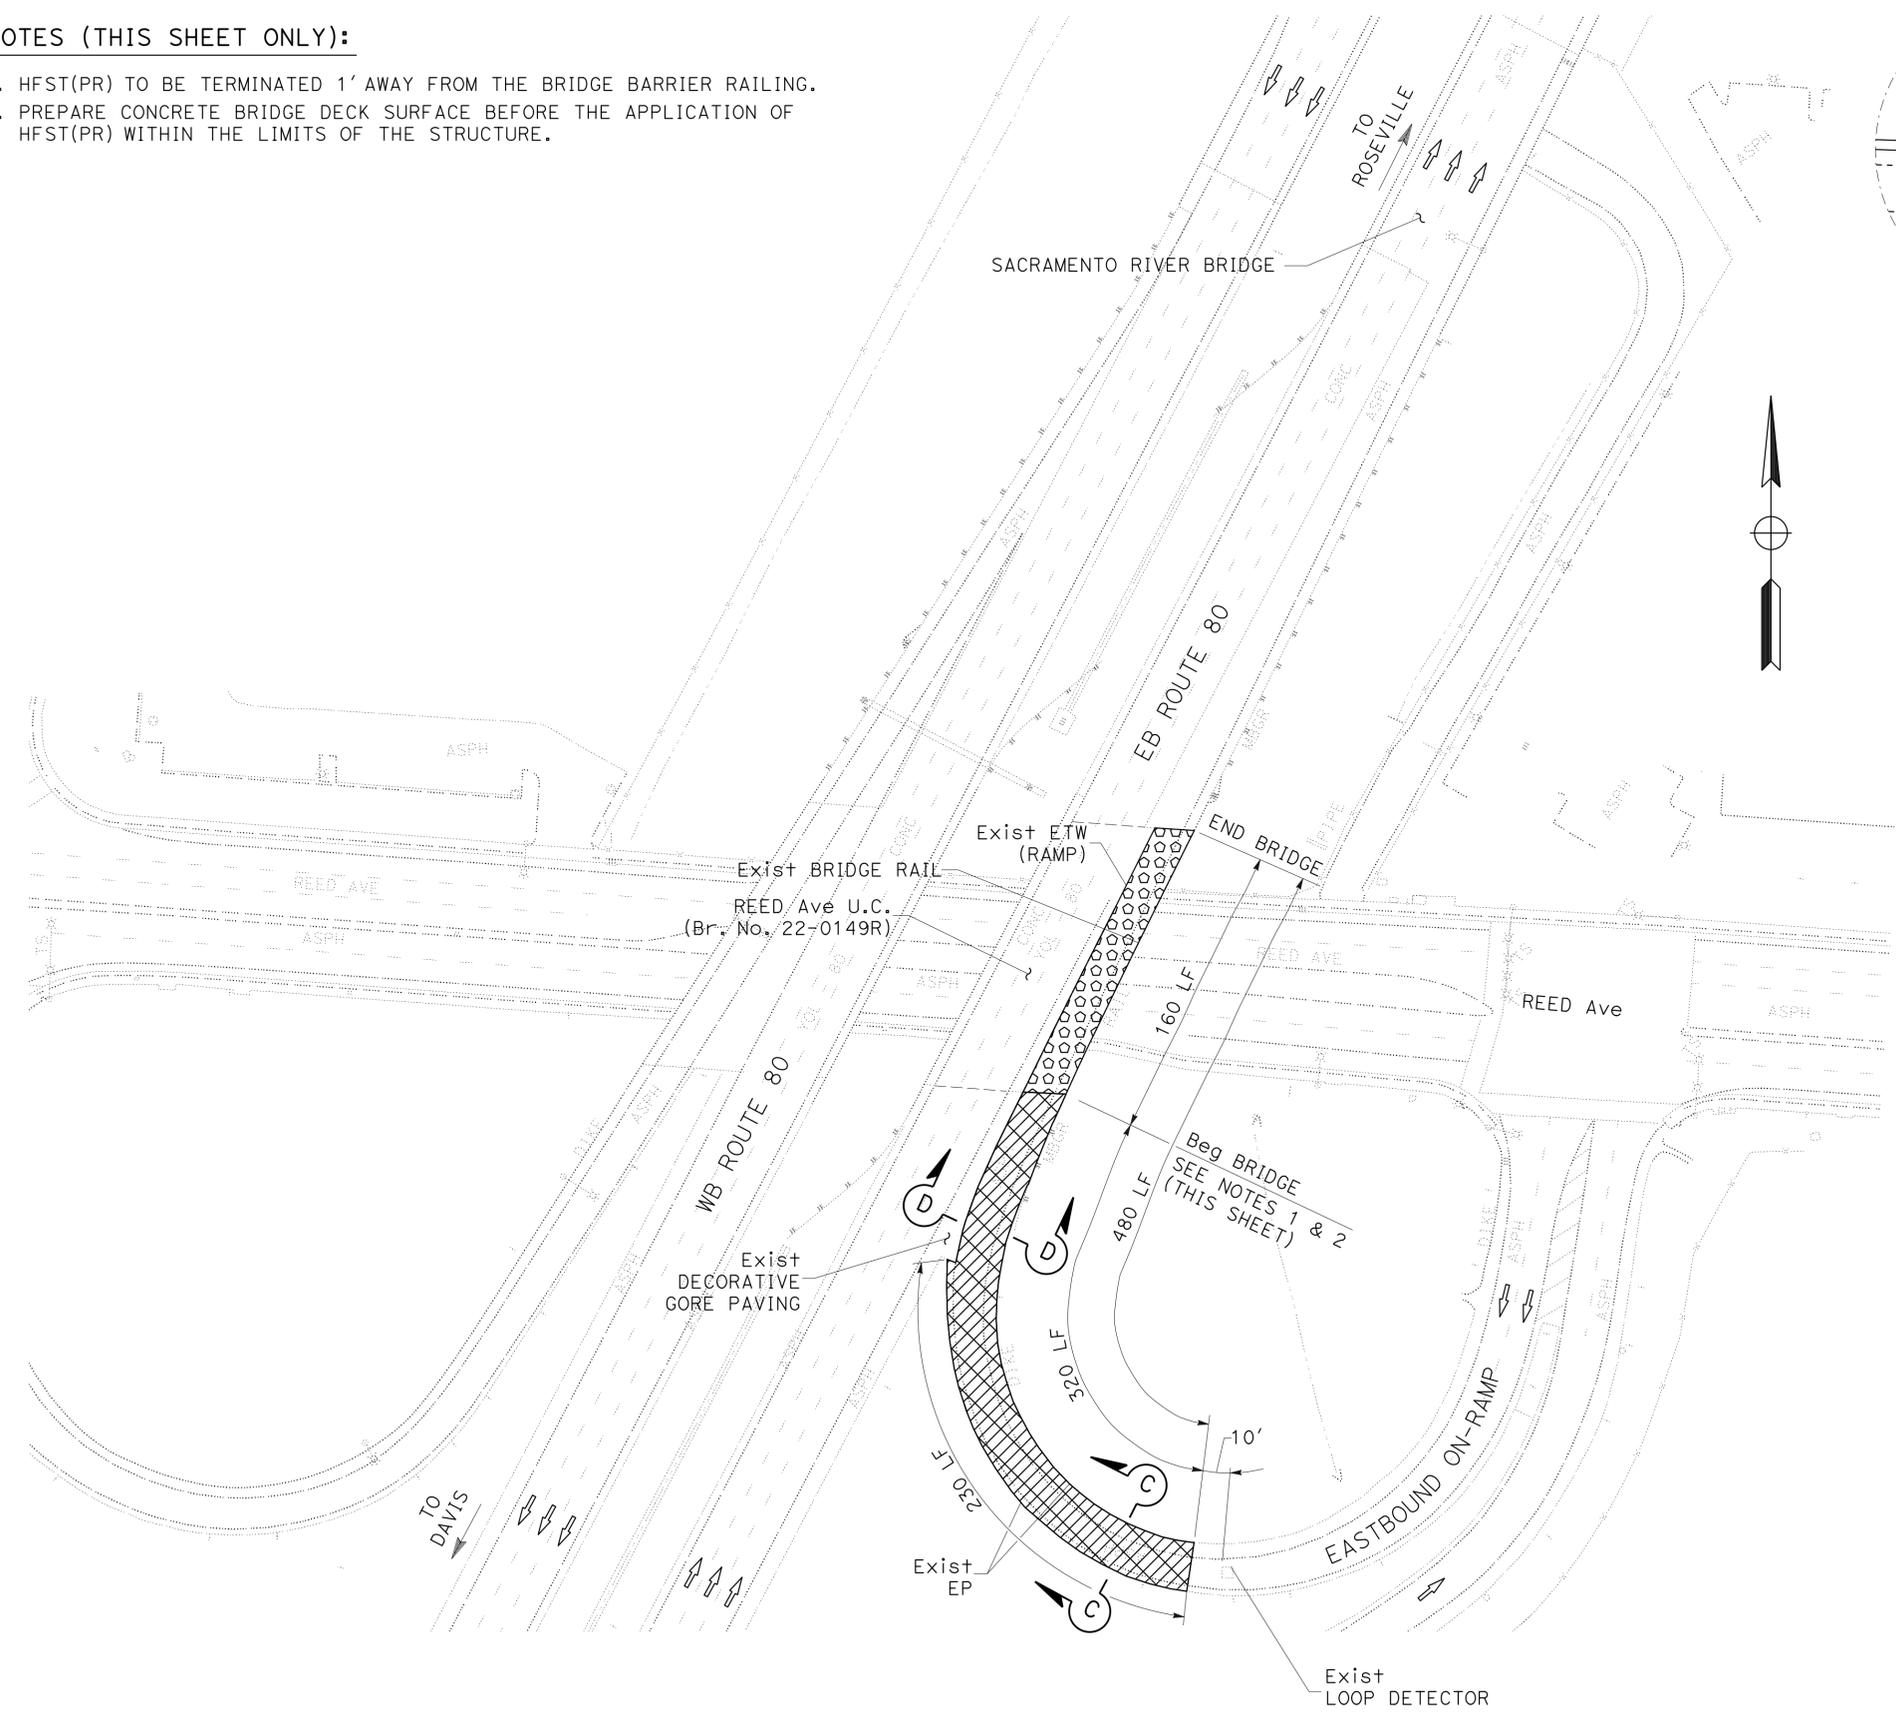

LOCATION 3
YOL-80 PM 11.2
EASTBOUND ON-RAMP FROM REED Ave



Dist	COUNTY	ROUTE	POST MILES TOTAL PROJECT	SHEET No.	TOTAL SHEETS
03	ED, Sac, Yoi	49, 50, 80	Var	4	25

1-27-15
 REGISTERED CIVIL ENGINEER DATE


1-27-15
 PLANS APPROVAL DATE

THE STATE OF CALIFORNIA OR ITS OFFICERS OR AGENTS SHALL NOT BE RESPONSIBLE FOR THE ACCURACY OR COMPLETENESS OF SCANNED COPIES OF THIS PLAN SHEET.

REGISTERED PROFESSIONAL ENGINEER
 DAVINDER MINHAS
 No. 70022
 Exp. 09/30/16
 CIVIL
 STATE OF CALIFORNIA

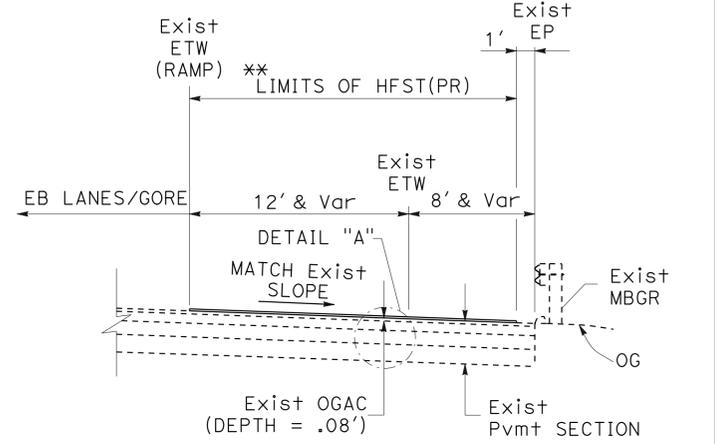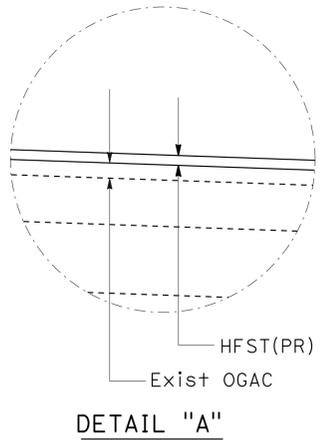

** APPLY 2 LAYERS OF HFST(PR) UP TO THE BEGINNING OF BRIDGE

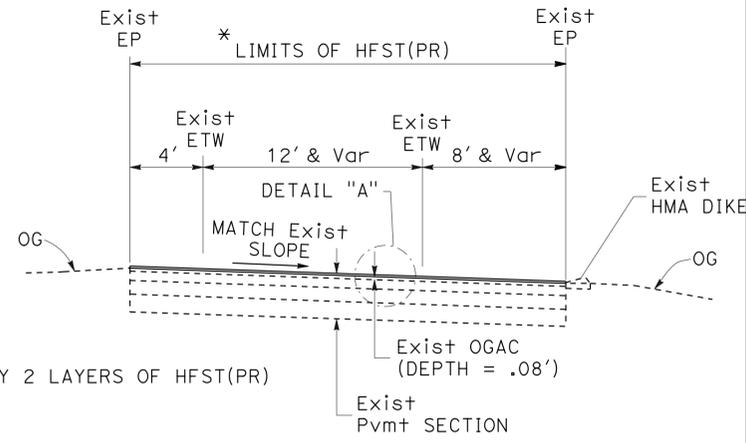

* APPLY 2 LAYERS OF HFST(PR)

CONSTRUCTION DETAILS

NO SCALE

C-3

Dist	COUNTY	ROUTE	POST MILES TOTAL PROJECT	SHEET No.	TOTAL SHEETS
03	ED, Sac, Yoi	49, 50, 80	Var	5	25



Davinder Minhas 1-27-15
 REGISTERED CIVIL ENGINEER DATE
 1-27-15
 PLANS APPROVAL DATE

REGISTERED PROFESSIONAL ENGINEER
 DAVINDER MINHAS
 No. 70022
 Exp. 09/30/16
 CIVIL
 STATE OF CALIFORNIA



THE STATE OF CALIFORNIA OR ITS OFFICERS OR AGENTS SHALL NOT BE RESPONSIBLE FOR THE ACCURACY OR COMPLETENESS OF SCANNED COPIES OF THIS PLAN SHEET.

NOTE (THIS SHEET ONLY):

1. APPLY HFST(PR) ON ROUTE 80 UP TO THE WEST END OF THE STRUCTURE AT ELKHORN Blvd O.C.

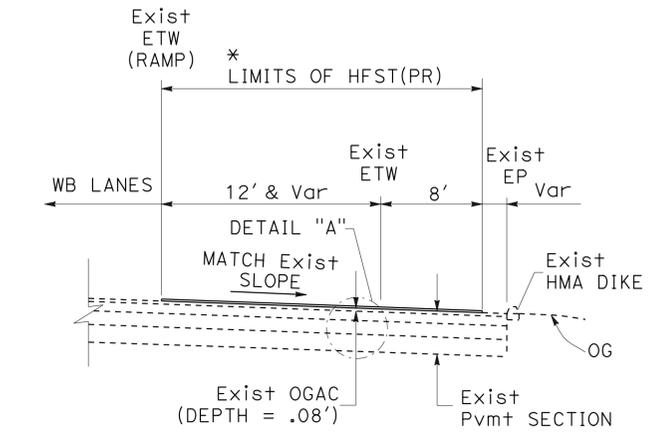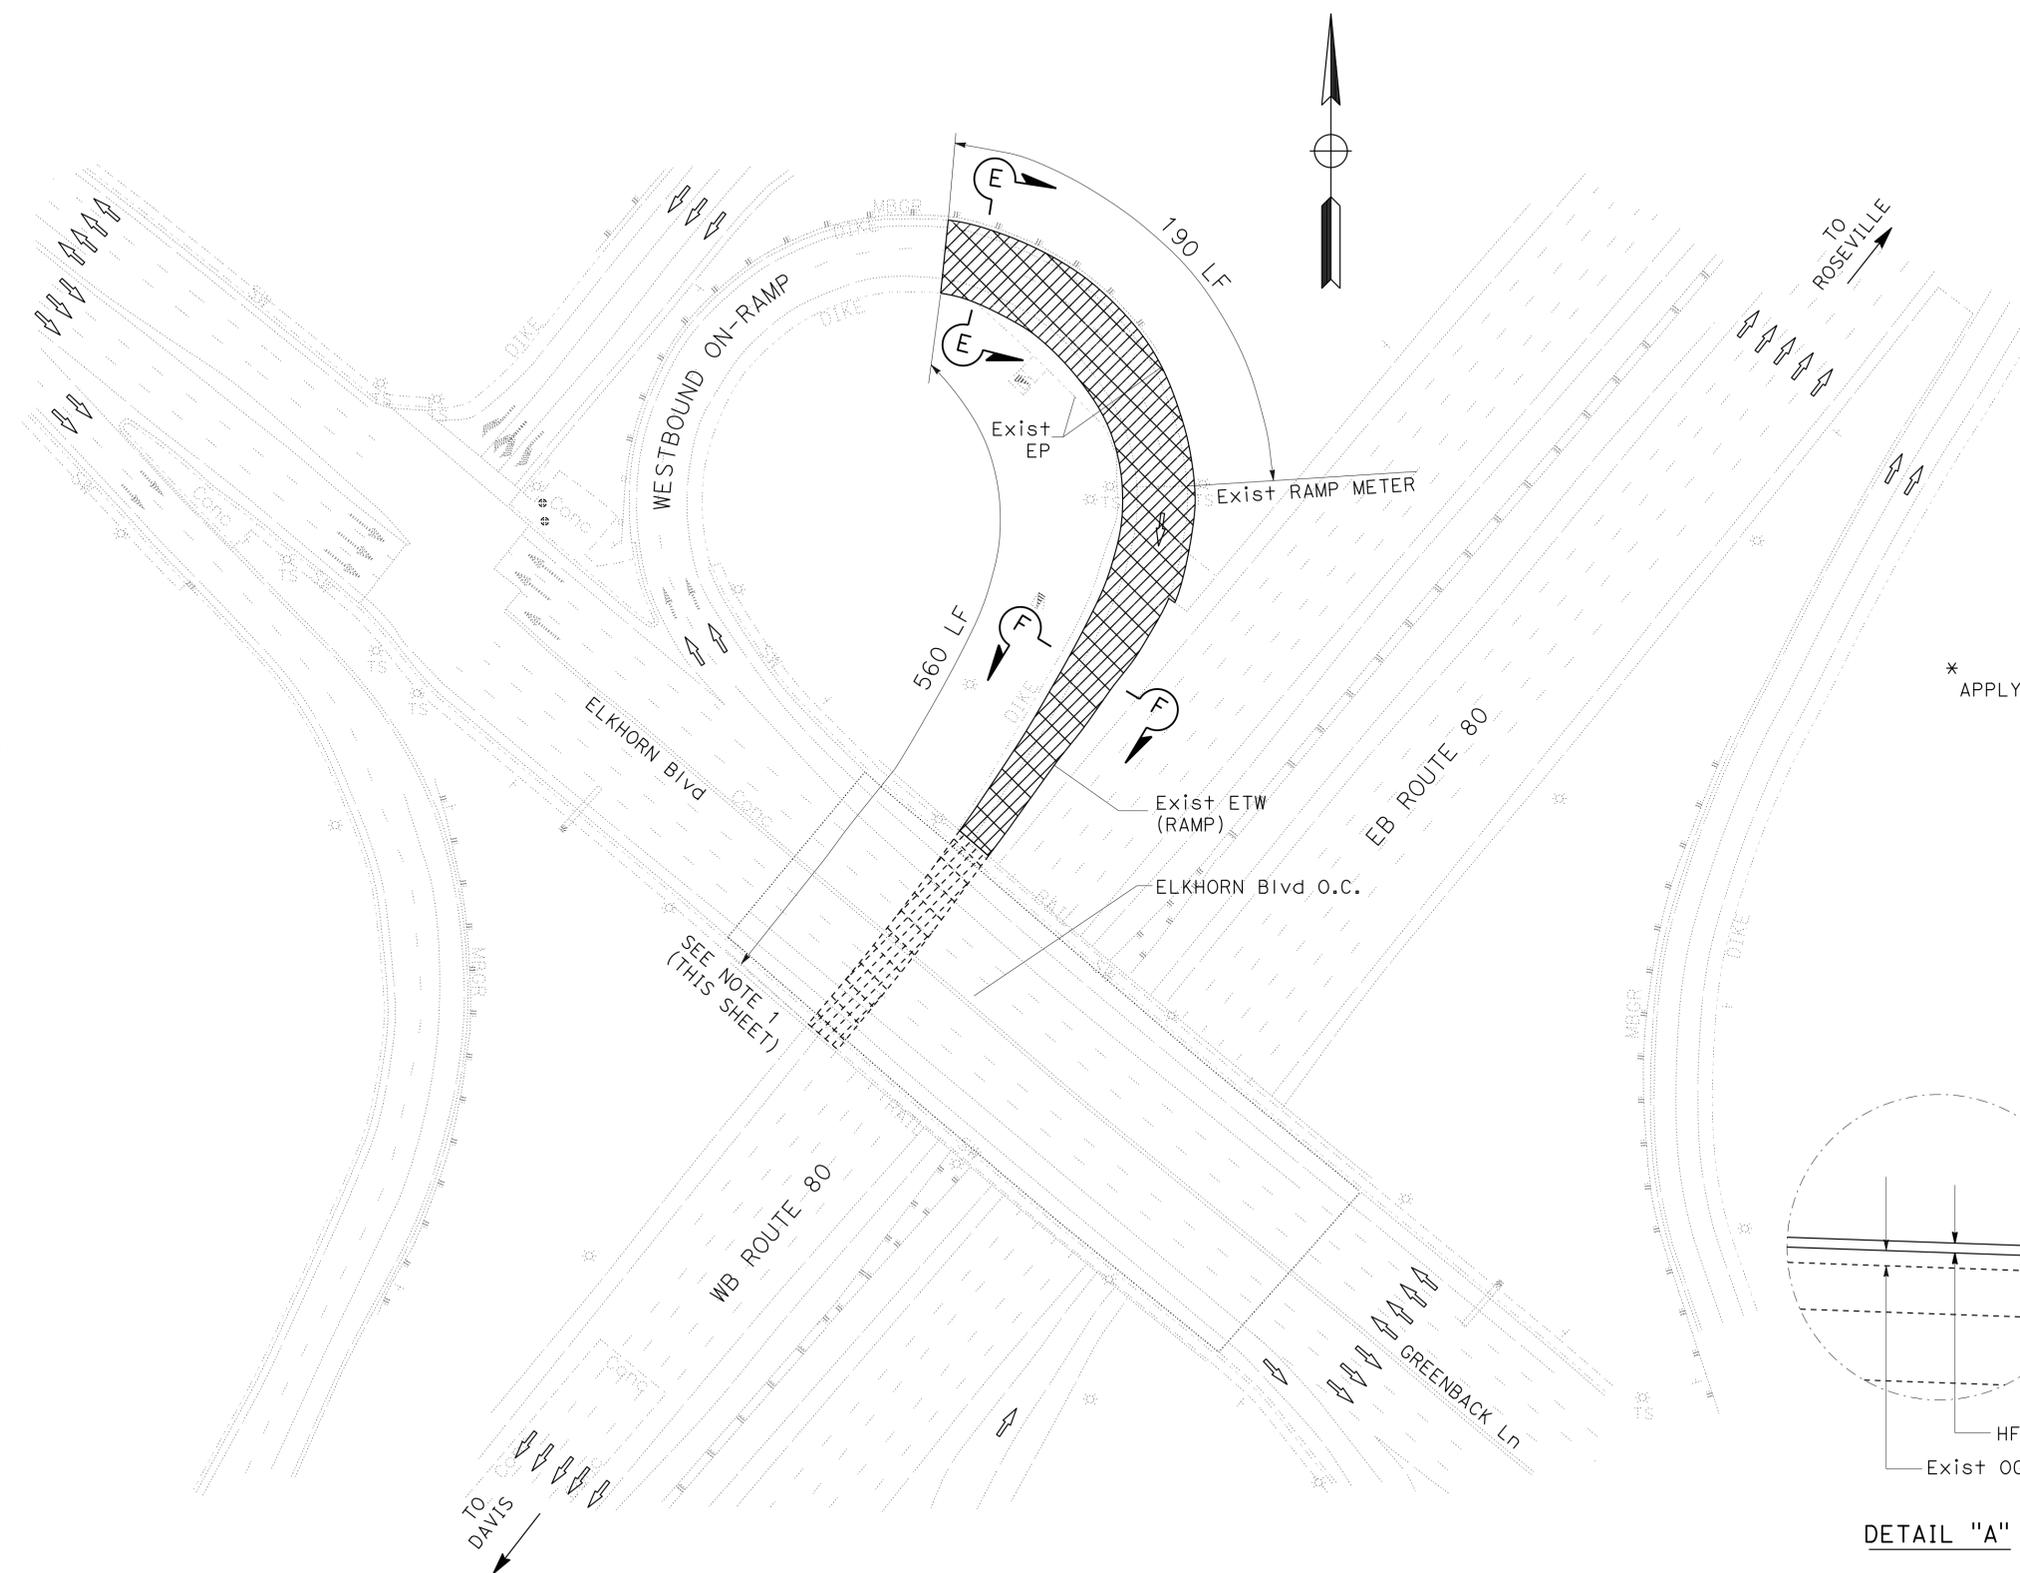

* APPLY 2 LAYERS OF HFST(PR)

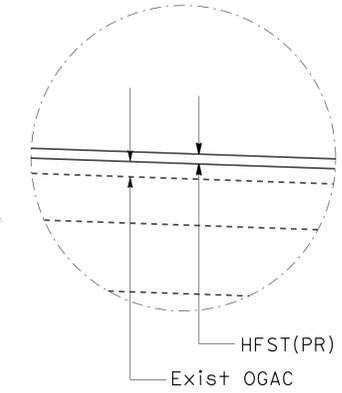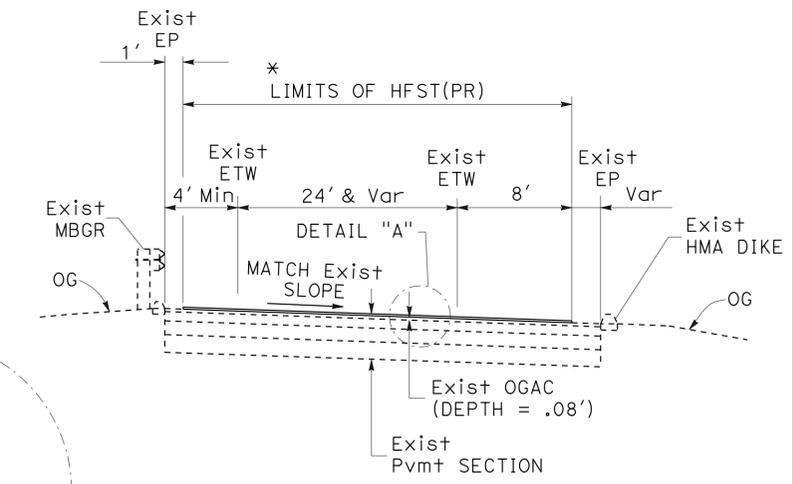

DETAIL "A"

LOCATION 4
SAC-80 PM 14.5
WESTBOUND ON-RAMP FROM ELKHORN Blvd

CONSTRUCTION DETAILS

NO SCALE

STATE OF CALIFORNIA - DEPARTMENT OF TRANSPORTATION	FUNCTIONAL SUPERVISOR	REVISOR	DATE
Caltrans	MIKE HAGEN	DAVINDER MINHAS	
TRAFFIC SAFETY		DENNIS CORCORAN	
		CALCULATED/DESIGNED BY	CHECKED BY

STATIONARY MOUNTED CONSTRUCTION AREA SIGNS

SIGN LETTER	SIGN CODE	PANEL SIZE	SIGN MESSAGE	NUMBER OF POST AND SIZE	NUMBER OF SIGNS
A	W20-1	48" x 48"	ROAD WORK AHEAD	1 - 6" x 6"	6
C	G20-2	36" x 18"	END ROAD WORK	1 - 4" x 4"	5
D	W20-1	60" x 60"	ROAD WORK AHEAD	2 - 4" x 6"	2
E	C14<CA>	48" x 24"	END ROAD WORK	1 - 4" x 6"	2

LEGEND



Dist	COUNTY	ROUTE	POST MILES TOTAL PROJECT	SHEET No.	TOTAL SHEETS
03	ED, Sac Yolo	49, 50 80	Var	6	25

KRIS M. ALBERS 1-27-15
 REGISTERED CIVIL ENGINEER DATE

1-27-15
 PLANS APPROVAL DATE


THE STATE OF CALIFORNIA OR ITS OFFICERS OR AGENTS SHALL NOT BE RESPONSIBLE FOR THE ACCURACY OR COMPLETENESS OF SCANNED COPIES OF THIS PLAN SHEET.

REGISTERED PROFESSIONAL ENGINEER
 KRIS M. ALBERS
 No. 49986
 Exp. 6-30-15
 CIVIL
 STATE OF CALIFORNIA

NOTES:

1. EXACT SIGN LOCATION TO BE DETERMINED BY THE ENGINEER.
2. ALL SIGN CODES SHOWN ARE FEDERAL SIGN CODES UNLESS OTHERWISE DESIGNATED AS A CALIFORNIA SIGN CODE.
3. <CA> = CALIFORNIA SIGN CODE.

REVISOR: KRIS ALBERS, CHUCK COOK
 DESIGNED BY: SERGIO ACEVES
 CHECKED BY: SERGIO ACEVES
 DATE: 1-27-15

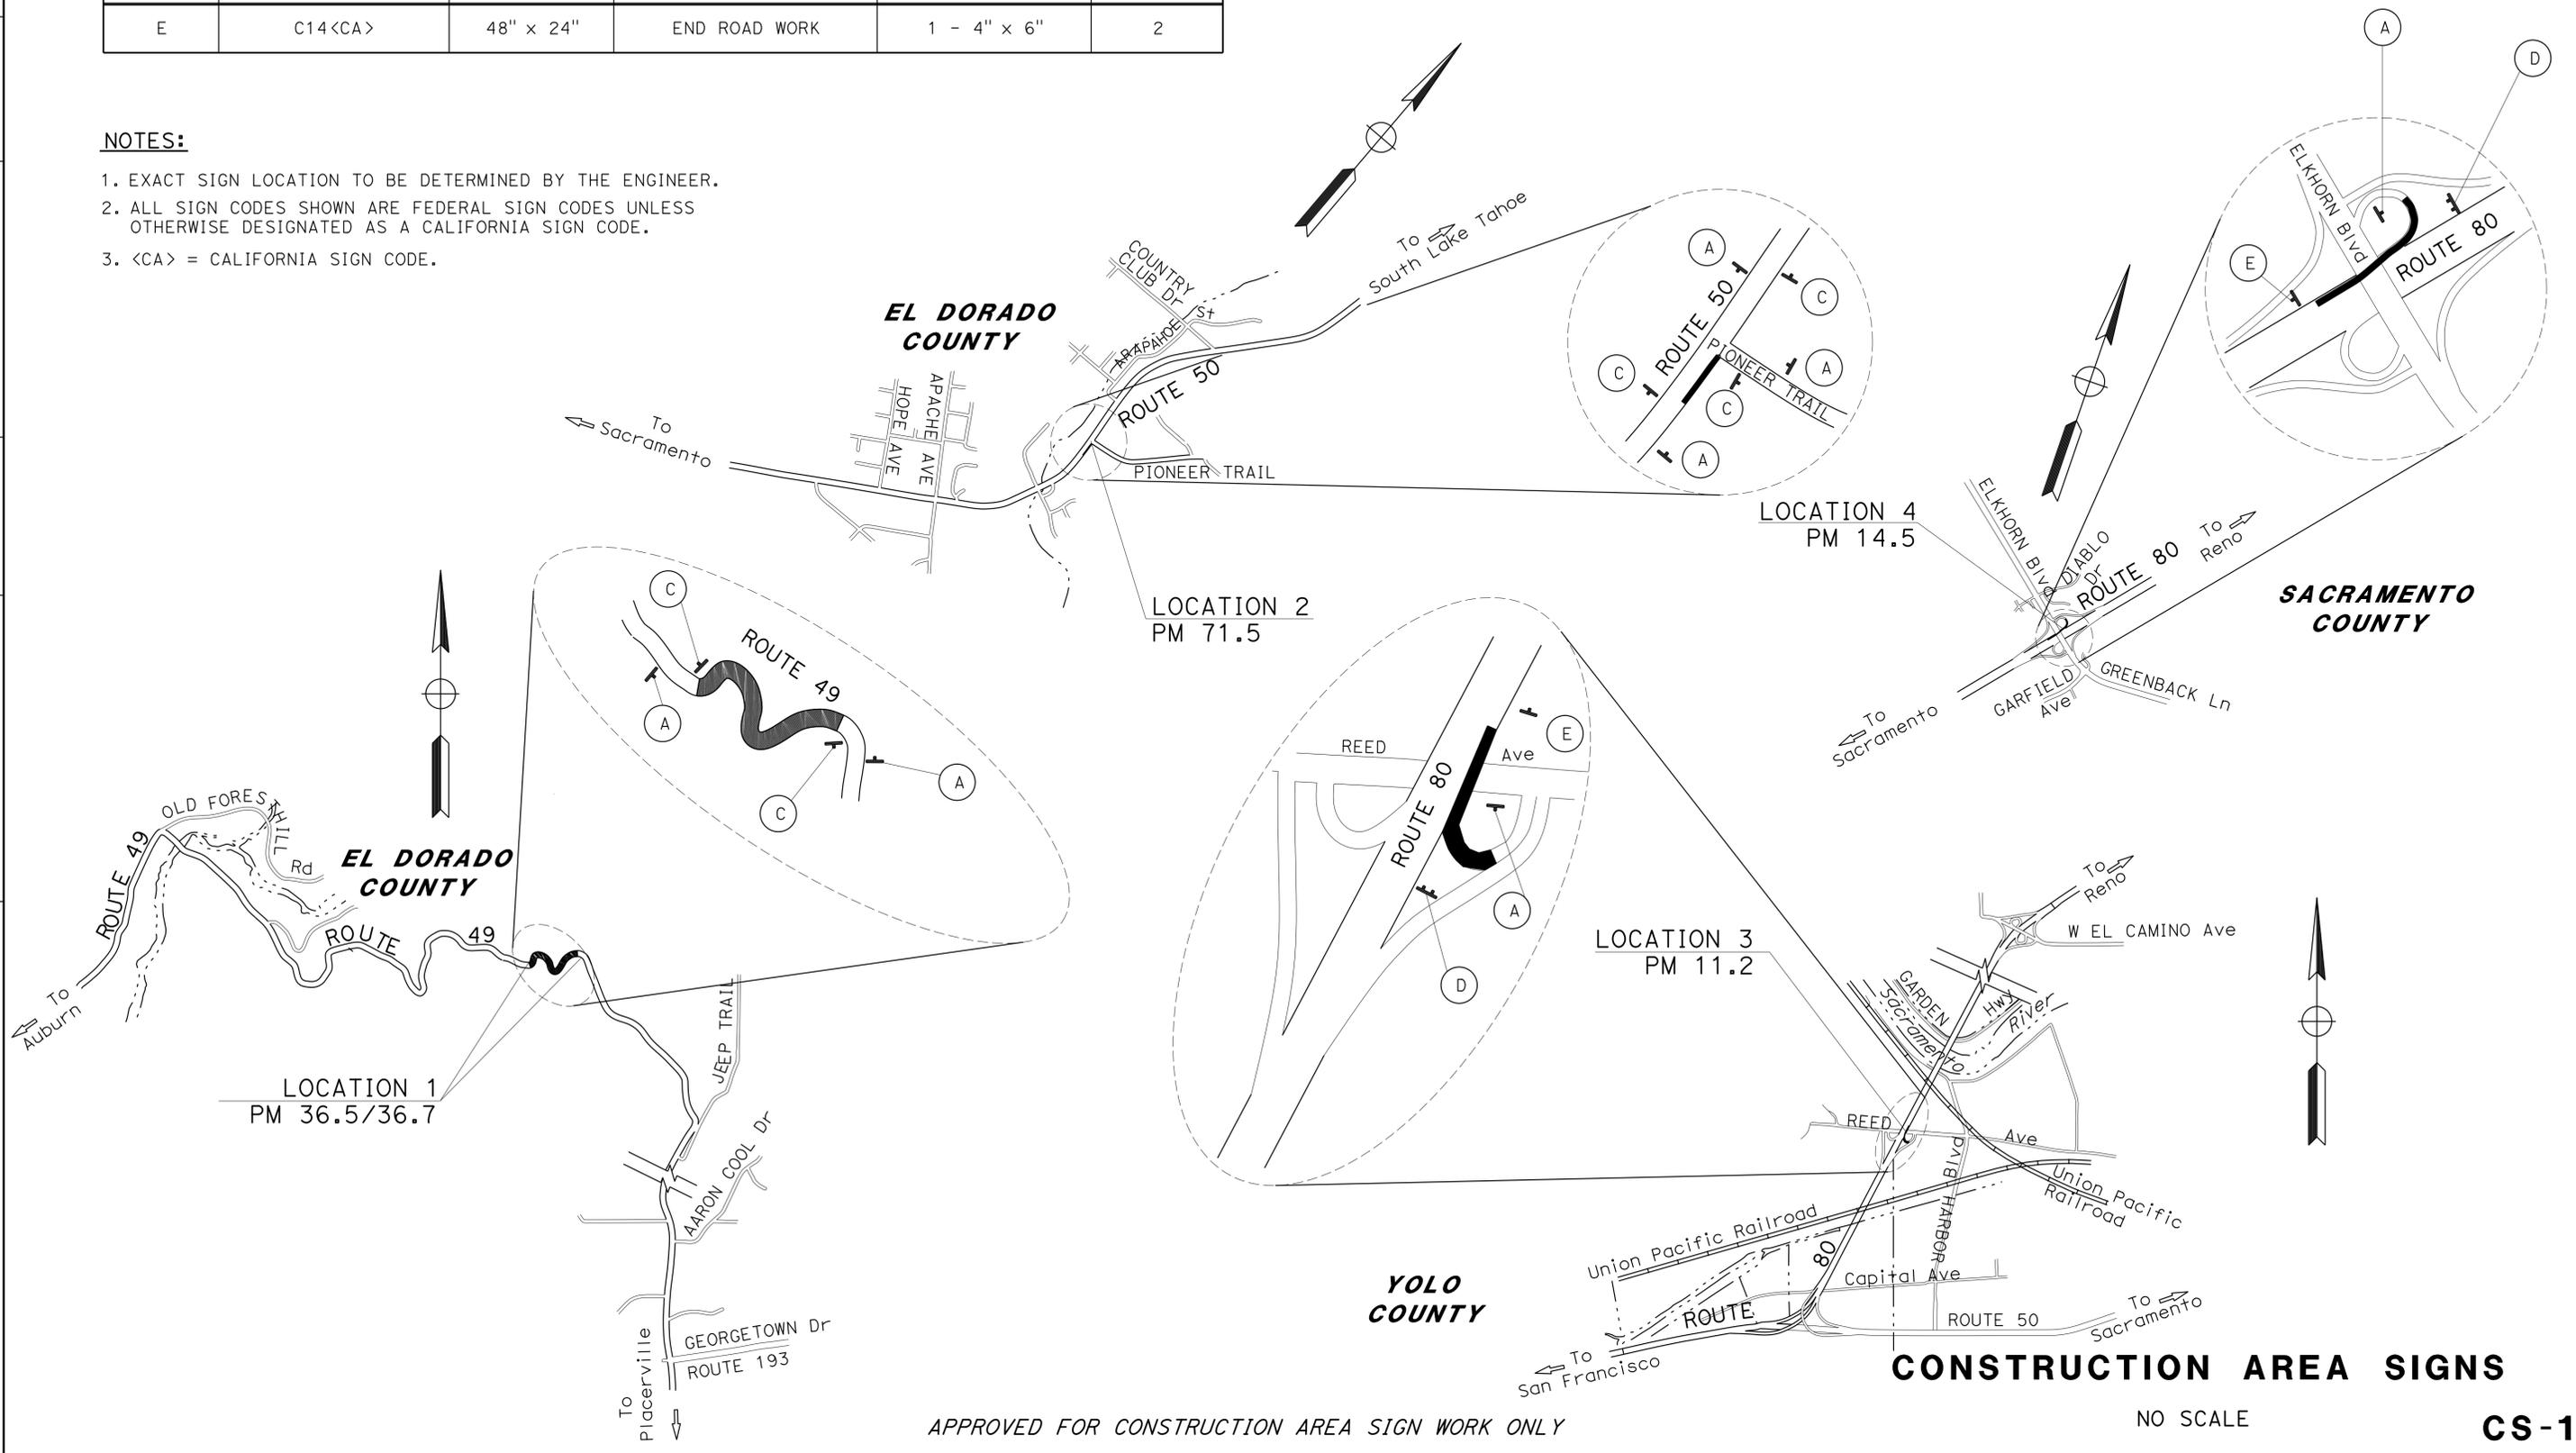

APPROVED FOR CONSTRUCTION AREA SIGN WORK ONLY

CONSTRUCTION AREA SIGNS

NO SCALE

CS-1

Dist	COUNTY	ROUTE	POST MILES TOTAL PROJECT	SHEET No.	TOTAL SHEETS
03	ED,Sac Yol	49,50 80	Var	7	25

Kris M. Albers 1-27-15
 REGISTERED CIVIL ENGINEER DATE

1-27-15
 PLANS APPROVAL DATE


No. 49986
 Exp. 6-30-15
 CIVIL

THE STATE OF CALIFORNIA OR ITS OFFICERS OR AGENTS SHALL NOT BE RESPONSIBLE FOR THE ACCURACY OR COMPLETENESS OF SCANNED COPIES OF THIS PLAN SHEET.

PAVEMENT DELINEATION QUANTITIES

LOCATION	4" THERMOPLASTIC TRAFFIC STRIPE (EWNV)								REMOVE YELLOW THERMOPLASTIC TRAFFIC STRIPE (HAZARDOUS WASTE)	REMOVE THERMOPLASTIC TRAFFIC STRIPE
	DETAIL 22	DETAIL 25A	DETAIL 27B	DETAIL 9	DETAIL 27B	DETAIL 36A	DETAIL 38A			
	LF	LF	LF	LF	LF	LF	LF	LF		
LOCATION 1	2800		2800					2800	2800	
LOCATION 2					250		230		710	
LOCATION 3		245	480	50		265		245	1060	
LOCATION 4		280	560	280		235		280	1112	
SUBTOTAL	2800	525	3840	330	250	500	230	3325	5682	
TOTAL		7165		330	250	500	230	3325	5682	

EWNV: ENHANCED WET NIGHT VISIBILITY

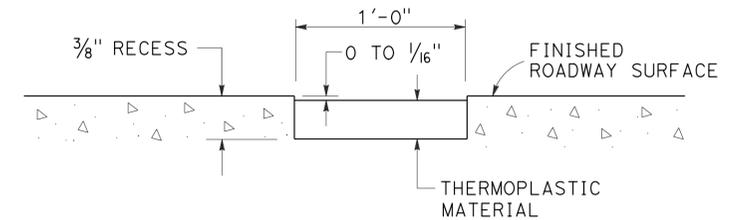

LIMIT LINE AND CROSSWALK RECESSING DETAIL

REMOVE THERMOPLASTIC PAVEMENT MARKING

DESCRIPTION	NUMBER	SQFT
TYPE III ARROW	2	84
LIMIT LINE (SEE NOTE)	2	70
TOTAL		154

THERMOPLASTIC PAVEMENT MARKING (RECESSED)

DESCRIPTION	NUMBER	SQFT
LIMIT LINE	1	40
TOTAL		40

TWO-COMPONENT PAINT PAVEMENT MARKING

DESCRIPTION	NUMBER	SQFT
TYPE III ARROW	2	84
TOTAL		84

PAVEMENT MARKER

DETAIL NUMBER	RETROREFLECTIVE		
	TYPE D EA	TYPE G EA	TYPE H EA
22	120		
25A			23
9		9	
36A		23	
SUBTOTAL	120	32	23
TOTAL		175	

THERMOPLASTIC PAVEMENT MARKING (EWNV)

DESCRIPTION	NUMBER	SQFT
LIMIT LINE	1	30
TOTAL		30

NOTE:

AT LOCATION 2, EXISTING THERMOPLASTIC TRAFFIC STRIPE AND EXISTING THERMOPLASTIC PAVEMENT MARKING (LIMIT LINE) ARE RECESSED.

PAVEMENT DELINEATION QUANTITIES

PDQ-1

STATE OF CALIFORNIA - DEPARTMENT OF TRANSPORTATION
Caltrans TRAFFIC SAFETY

FUNCTIONAL SUPERVISOR
 MIKE HAGEN

CALCULATED/DESIGNED BY
 CHECKED BY

DAVINDER MINHAS
 DENNIS CORCORAN

REVISED BY
 DATE REVISED

Dist	COUNTY	ROUTE	POST MILES TOTAL PROJECT	SHEET No.	TOTAL SHEETS
03	ED, Sac, Yolo	49, 50, 80	Var	8	25

Davinder Minhas 1-27-15
 REGISTERED CIVIL ENGINEER DATE

1-27-15
 PLANS APPROVAL DATE

THE STATE OF CALIFORNIA OR ITS OFFICERS OR AGENTS SHALL NOT BE RESPONSIBLE FOR THE ACCURACY OR COMPLETENESS OF SCANNED COPIES OF THIS PLAN SHEET.

ROADWAY QUANTITIES

LOCATION	HIGH FRICTION SURFACE TREATMENT (POLYMER RESIN)	REPLACE ASPHALT CONCRETE SURFACING
	SQYD	CY
LOCATION 1: ED-49 PM 36.5/36.7	4,110	
LOCATION 2: ED-50 PM 71.5	680	60
LOCATION 3: Yolo-80 PM 11.2	2,240	
LOCATION 4: Sac-80 PM 14.5	4,160	
TOTAL	11,190	60



TEMPORARY WATER POLLUTION CONTROL

LOCATION	TEMPORARY DRAINAGE INLET PROTECTION
	EA
LOCATION 2: ED-50 PM 71.5	2
LOCATION 4: Sac-80 PM 14.5	1
TOTAL	3

SUMMARY OF QUANTITIES
Q-1

LAST REVISION | DATE PLOTTED => 01-APR-2015 00-00-00 TIME PLOTTED => 15:37

Dist	COUNTY	ROUTE	POST MILES TOTAL PROJECT	SHEET No.	TOTAL SHEETS
03	ED, Sac, Yoi	49,50, 80	Var	9	25
R. P. Gill			1-27-15		
REGISTERED ELECTRICAL ENGINEER			DATE		
1-27-15			PLANS APPROVAL DATE		
<small>THE STATE OF CALIFORNIA OR ITS OFFICERS OR AGENTS SHALL NOT BE RESPONSIBLE FOR THE ACCURACY OR COMPLETENESS OF SCANNED COPIES OF THIS PLAN SHEET.</small>					

 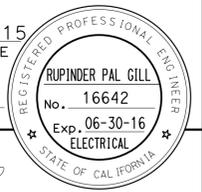

NOTES:



- FOR ACCURATE RIGHT OF WAY DATA, CONTACT RIGHT OF WAY ENGINEERING AT THE DISTRICT OFFICE.
- FOR TRAFFIC PULL BOX WELDING DETAIL SEE SHEET E-3
- EXISTING UTILITY FACILITIES HAVE NOT BEEN PLOTTED ON THESE PLANS.

LEGEND (THIS SHEET ONLY):


- 1 [RC] EXISTING PB, [dh]
- 2 [AB] EXISTING CONDUIT BETWEEN [dh] AND EXISTING PB, [SC]

ABBREVIATION AND SYMBOLS:

- ETR ELECTRONIC TAG READER
- LE LIBERTY ENERGY
- ETR ANTENNA:

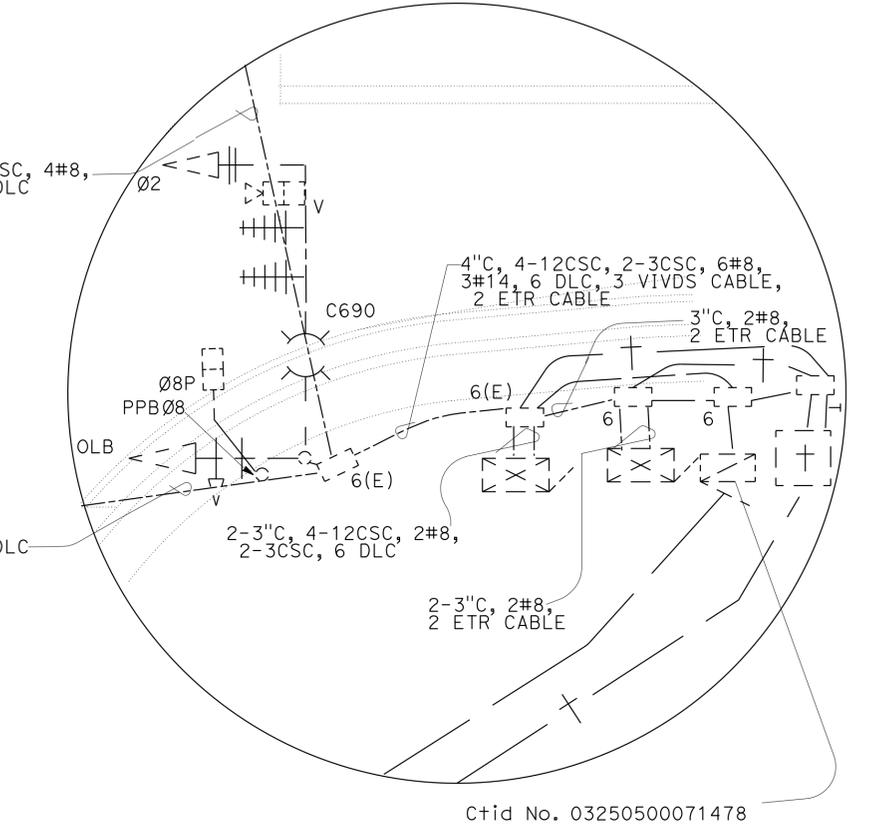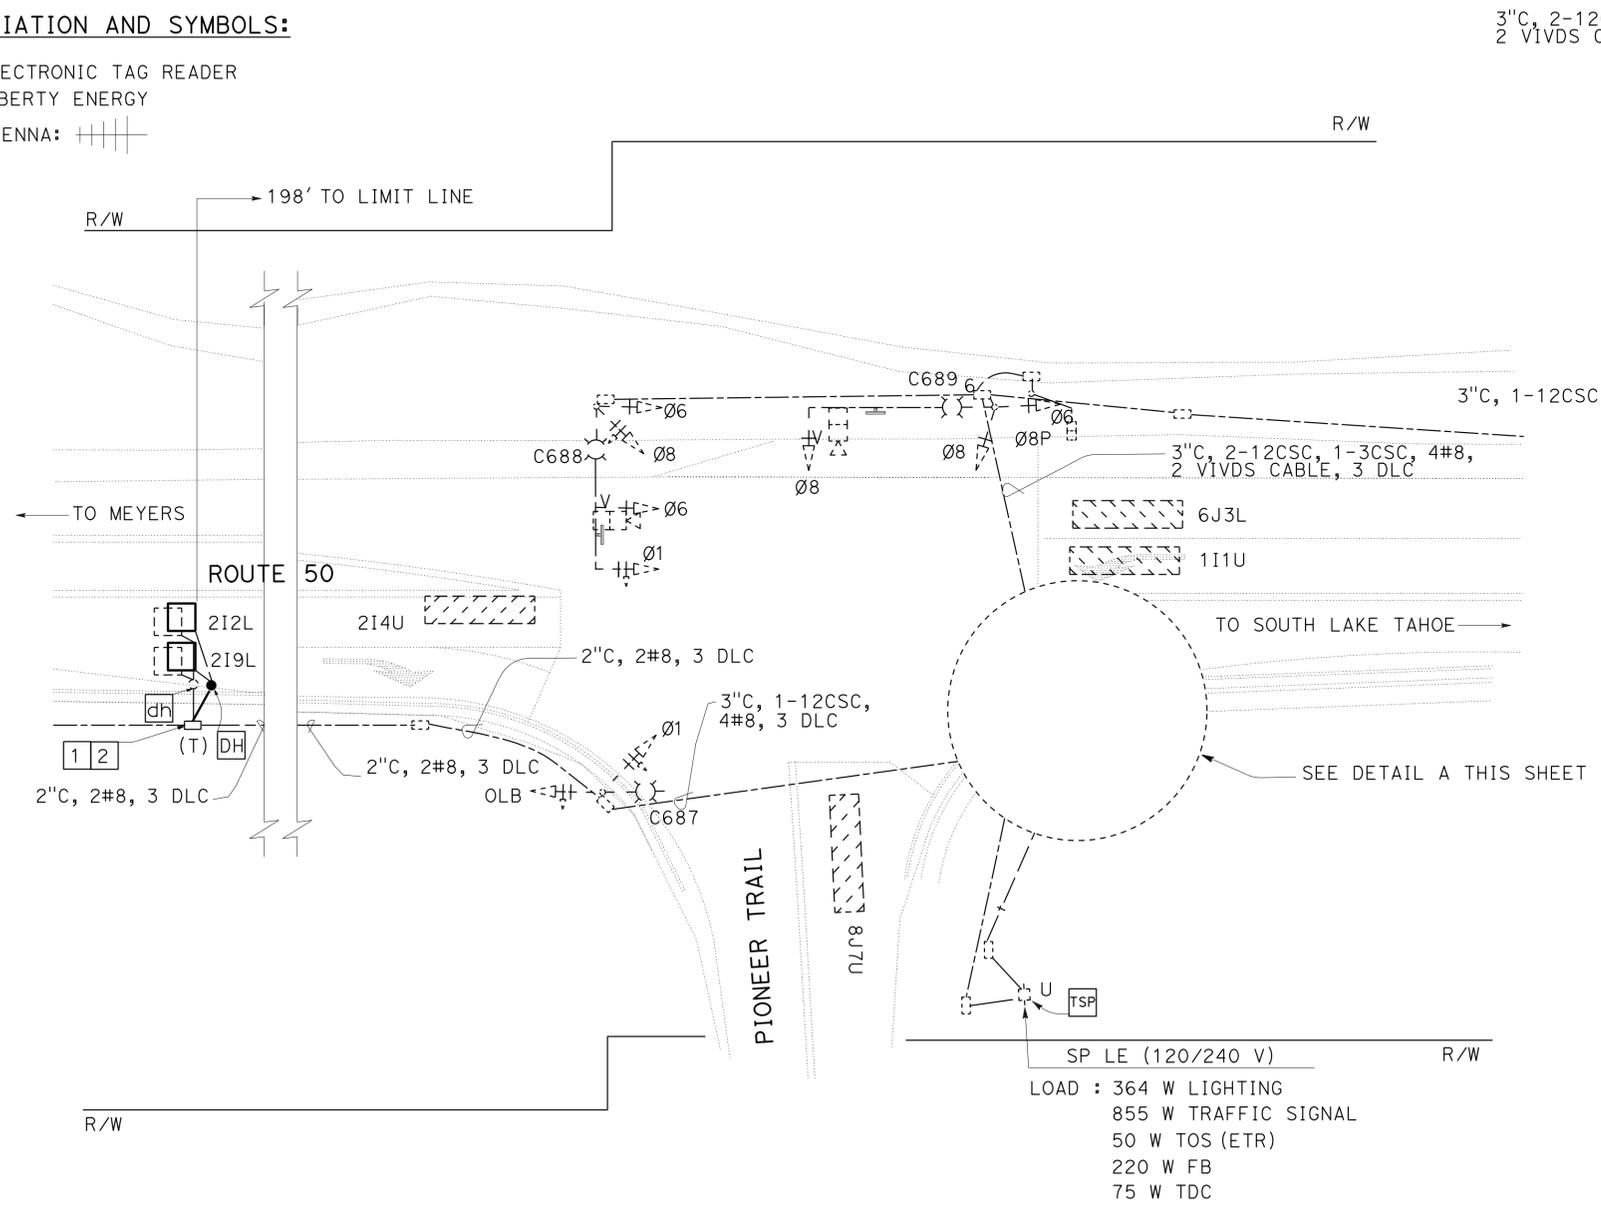

DETAIL A
NO SCALE

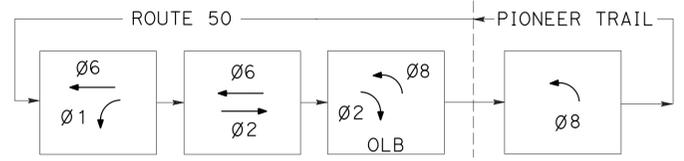

EXISTING PHASE DIAGRAM
(NO CHANGES)

MODIFY SIGNAL
SCALE: 1" = 20'

APPROVED FOR ELECTRICAL WORK ONLY

STATE OF CALIFORNIA - DEPARTMENT OF TRANSPORTATION
Caltrans ELECTRICAL DESIGN
 FUNCTIONAL SUPERVISOR: MARY ANN HUDSPETH
 CALCULATED/DESIGNED BY: ZAHRA NIKNAFS
 CHECKED BY: RUPINDER PAL GILL
 REVISIONS: (None shown)

STATE OF CALIFORNIA - DEPARTMENT OF TRANSPORTATION
Caltrans® ELECTRICAL DESIGN

FUNCTIONAL SUPERVISOR
 MARY ANN HUDSPETH

CALCULATED/DESIGNED BY
 CHECKED BY

ZARHA NIKNAFS
 RUPINDER PAL GILL

REVISED BY
 DATE REVISED

NOTE:

1. ITEMS SHOWN IN TABLES ARE NOT A SEPARATE PAY ITEM, FOR INFORMATION ONLY.

Dist	COUNTY	ROUTE	POST MILES TOTAL PROJECT	SHEET No.	TOTAL SHEETS
03	ED, Sac, Yolo	49, 50, 80	Var	12	25

R. P. Gill 1-27-15
 REGISTERED ELECTRICAL ENGINEER DATE

1-27-15
 PLANS APPROVAL DATE

REGISTERED PROFESSIONAL ENGINEER
 RUPINDER PAL GILL
 No. 16642
 Exp. 06-30-16
 ELECTRICAL
 STATE OF CALIFORNIA

THE STATE OF CALIFORNIA OR ITS OFFICERS OR AGENTS SHALL NOT BE RESPONSIBLE FOR THE ACCURACY OR COMPLETENESS OF SCANNED COPIES OF THIS PLAN SHEET.

MODIFY SIGNAL

SHEET No.	TYPE A LOOP	DETECTOR HANDHOLE	No. 5 TRAFFIC PB
	EA	EA	EA
E-1	2	1	1

TRAFFIC MONITORING STATION (COUNT)

SHEET No.	TYPE A LOOP 6'X10'	DLC	DETECTOR HANDHOLE	No. 5 TRAFFIC PB	2" C CONDUIT
	EA	FT	EA	EA	FT
E-2	6	1700	4	1	130

ELECTRICAL QUANTITIES

E-4

	M	
Maint	MAINTENANCE	
Max	MAXIMUM	
MB	METAL BEAM	
MBB	METAL BEAM BARRIER	
MBGR	METAL BEAM GUARD RAILING	
Med	MEDIAN	
MGS	MIDWEST GUARDRAIL SYSTEM	
MH	MANHOLE	
Min	MINIMUM	
Misc	MISCELLANEOUS	
Misc I & S	MISCELLANEOUS IRON AND STEEL	
Mkr	MARKER	
Mod	MODIFIED, MODIFY	
Mon	MONUMENT	
MP	METAL PLATE	
MPGR	METAL PLATE GUARD RAILING	
MR	MOVEMENT RATING	
MSE	MECHANICALLY STABILIZED EMBANKMENT	
Mt	MOUNTAIN, MOUNT	
MtI	MATERIAL	
MVP	MAINTENANCE VEHICLE PULLOUT	
	N	
N	NORTH	
NB	NORTHBOUND	
No.	NUMBER (MUST HAVE PERIOD)	
Nos.	NUMBERS (MUST HAVE PERIOD)	
NPS	NOMINAL PIPE SIZE	
NS	NEAR SIDE	
NSP	NEW STANDARD PLAN	
NTS	NOT TO SCALE	
	O	
Obir	OBLITERATE	
OC	OVERCROSSING	
OD	OUTSIDE DIAMETER	
OF	OUTSIDE FACE	
OG	ORIGINAL GROUND	
OGAC	OPEN GRADED ASPHALT CONCRETE	
OGFC	OPEN GRADED FRICTION COURSE	
OH	OVERHEAD	
OHWM	ORDINARY HIGH WATER MARK	
O-O	OUT TO OUT	
Opp	OPPOSITE	
OSD	OVERSIDE DRAIN	
	P	
p	PAGE	
PAP	PERFORATED ALUMINUM PIPE	
PB	PULL BOX	
PC	POINT OF CURVATURE, PRECAST	
PCC	POINT OF COMPOUND CURVE, PORTLAND CEMENT CONCRETE	
PCMS	PORTABLE CHANGEABLE MESSAGE SIGN	
PCP	PERFORATED CONCRETE PIPE, PRESTRESSED CONCRETE PIPE	
PCVC	POINT OF COMPOUND VERTICAL CURVE	
PEC	PERMIT TO ENTER AND CONSTRUCT	
Ped	PEDESTRIAN	
Ped OC	PEDESTRIAN OVERCROSSING	
Ped UC	PEDESTRIAN UNDERCROSSING	
Perm MtI	PERMEABLE MATERIAL	

	P continued	
PG	PROFILE GRADE	
PI	POINT OF INTERSECTION	
PJP	PARTIAL JOINT PENETRATION	
Pkwy	PARKWAY	
PL, PL	PLATE	
P/L	PROPERTY LINE	
PM	POST MILE, TIME FROM NOON TO MIDNIGHT	
PN	PAVING NOTCH	
POC	POINT OF HORIZONTAL CURVE	
POT	POINT OF TANGENT	
POVC	POINT OF VERTICAL CURVE	
PP	PIPE PILE, PLASTIC PIPE, POWER POLE	
PPL	PREFORMED PERMEABLE LINER	
PPP	PERFORATED PLASTIC PIPE	
PRC	POINT OF REVERSE CURVE	
PRF	PAVEMENT REINFORCING FABRIC	
PRVC	POINT OF REVERSE VERTICAL CURVE	
PS&E	PLANS, SPECIFICATIONS AND ESTIMATES	
PS, P/S	PRESTRESSED	
PSP	PERFORATED STEEL PIPE	
PT	POINT OF TANGENCY	
PVC	POLYVINYL CHLORIDE	
Pvmt	PAVEMENT	
	Q	
Qty	QUANTITY	
	R	
R	RADIUS	
R & D	REMOVE AND DISPOSE	
R & S	REMOVE AND SALVAGE	
R/C	RATE OF CHANGE	
RCA	REINFORCED CONCRETE ARCH	
RCB	REINFORCED CONCRETE BOX	
RCP	REINFORCED CONCRETE PIPE	
RCPA	REINFORCED CONCRETE PIPE ARCH	
Rd	ROAD	
Reinf	REINFORCED, REINFORCEMENT, REINFORCING	
Rel	RELOCATE	
Repl	REPLACEMENT	
Ret	RETAINING	
Rev	REVISED, REVISION	
Rdwy	ROADWAY	
RHMA	RUBBERIZED HOT MIX ASPHALT	
Riv	RIVER	
RM	ROAD-MIXED	
RP	RADIUS POINT, REFERENCE POINT	
RR	RAILROAD	
RSP	ROCK SLOPE PROTECTION, REVISED STANDARD PLAN	
Rt	RIGHT	
Rte	ROUTE	
RW	REDWOOD, RETAINING WALL	
R/W	RIGHT OF WAY	
Rwy	RAILWAY	

	S	
S	SOUTH, SUPPLEMENT	
SAE	STRUCTURE APPROACH EMBANKMENT	
Salv	SALVAGE	
SAPP	STRUCTURAL ALUMINUM PLATE PIPE	
SB	SOUTHBOUND	
SC	SAND CUSHION	
SCSP	SLOTTED CORRUGATED STEEL PIPE	
SD	STORM DRAIN	
Sec	SECOND, SECTION	
Sep	SEPARATION	
SG	SUBGRADE	
Shld	SHOULDER	
Sht	SHEET	
Sim	SIMILAR	
ℒ	STATION LINE	
SM	SELECTED MATERIAL	
Spec	SPECIAL, SPECIFICATIONS	
SPP	SLOTTED PLASTIC PIPE	
SS	SLOPE STAKE	
SSBM	STRAP AND SADDLE BRACKET METHOD	
SSD	STRUCTURAL SECTION DRAIN	
SSPA	STRUCTURAL STEEL PLATE ARCH	
SSPP	STRUCTURAL STEEL PLATE PIPE	
SSPPA	STRUCTURAL STEEL PLATE PIPE ARCH	
SSRP	STEEL SPIRAL RIB PIPE	
St	STREET	
Sta	STATION	
STBB	SINGLE THRIE BEAM BARRIER	
Std	STANDARD	
Str	STRUCTURE	
Surf	SURFACING	
SW	SIDEWALK, SOUND WALL	
Swr	SEWER	
Sym	SYMMETRICAL	
S4S	SURFACE 4 SIDES	
	T	
T	SEMI-TANGENT	
Tan	TANGENT	
TBB	THRIE BEAM BARRIER	
Tbr	TIMBER	
TC	TOP OF CURB	
TCB	TRAFFIC CONTROL BOX	
TCE	TEMPORARY CONSTRUCTION EASEMENT	
TeI	TELEPHONE	
Temp	TEMPORARY	
TG	TOP OF GRADE	
Tot	TOTAL	
TP	TELEPHONE POLE	
TPB	TREATED PERMEABLE BASE	
TPM	TREATED PERMEABLE MATERIAL	
Trans	TRANSITION	

	T continued	
TS	TRANSVERSE, TRAFFIC SIGNAL, TUBULAR STEEL	
Typ	TYPICAL	U
UC	UNDERCROSSING	
UD	UNDERDRAIN	
UG	UNDERGROUND	
UON	UNLESS OTHERWISE NOTED	
UP	UNDERPASS	V
V	VALVE, DESIGN SPEED	
Var	VARIABLE, VARIES	W
VC	VERTICAL CURVE	
VCP	VITRIFIED CLAY PIPE	
Vert	VERTICAL	
Via	VIADUCT	
Vol	VOLUME	
W	WEST, WIDTH	
WB	WESTBOUND	
WH	WEEP HOLE	
WM	WIRE MESH	
WS	WATER SURFACE	
WSP	WELDED STEEL PIPE	
Wt	WEIGHT	
WV	WATER VALVE	
WW	WINGWALL	
WWLOL	WINGWALL LAYOUT LINE	X
X Sec	CROSS SECTION	
Xing	CROSSING	Y
Yr	YEAR	
Yrs	YEARS	

Dist	COUNTY	ROUTE	POST MILES TOTAL PROJECT	SHEET No.	TOTAL SHEETS
03	ED, Sac, Yol	49, 50, 80	Var	13	25

Grace M. Tsushima
REGISTERED CIVIL ENGINEER

July 19, 2013
PLANS APPROVAL DATE

REGISTERED PROFESSIONAL ENGINEER
Grace M. Tsushima
No. C49814
Exp. 9-30-14
CIVIL
STATE OF CALIFORNIA

THE STATE OF CALIFORNIA OR ITS OFFICERS OR AGENTS SHALL NOT BE RESPONSIBLE FOR THE ACCURACY OR COMPLETENESS OF SCANNED COPIES OF THIS PLAN SHEET.

TO ACCOMPANY PLANS DATED 1-27-15

UNIT OF MEASUREMENT SYMBOLS:

Some of the symbols used in the project plan quantity tables and in the Bid Item List are:

TABLE A

SYMBOL USED	DEFINITIONS
ACRE	ACRE
CF	CUBIC FOOT
CY	CUBIC YARD
EA	EACH
GAL	GALLON
LB	POUND
LF	LINEAR FOOT
SQFT	SQUARE FOOT
SQYD	SQUARE YARD
STA	100 FEET
TAB	TABLET
TON	2,000 POUNDS

Some of the symbols used in the plans other than in the project plan quantity tables are:

TABLE B

SYMBOL USED	DEFINITIONS
ksi	KIPS PER SQUARE INCH
ksf	KIPS PER SQUARE FOOT
psi	POUNDS PER SQUARE INCH
psf	POUNDS PER SQUARE FOOT
lb/ft ³ , pcf	POUNDS PER CUBIC FOOT
tsf	TONS PER SQUARE FOOT
mph, MPH *	MILES PER HOUR
∅	NOMINAL DIAMETER
oz	OUNCE
lb	POUND
kíp	1,000 POUNDS
cal	CALORIE
ft	FOOT OR FEET
gal	GALLON

* For use on a sign panel only


STATE OF CALIFORNIA
DEPARTMENT OF TRANSPORTATION

**ABBREVIATIONS
(SHEET 2 OF 2)**


NO SCALE

RSP A10B DATED JULY 19, 2013 SUPERSEDES STANDARD PLAN A10B
DATED MAY 20, 2011 - PAGE 2 OF THE STANDARD PLANS BOOK DATED 2010.


EXIT RAMP NEUTRAL AREA (GORE) TREATMENT

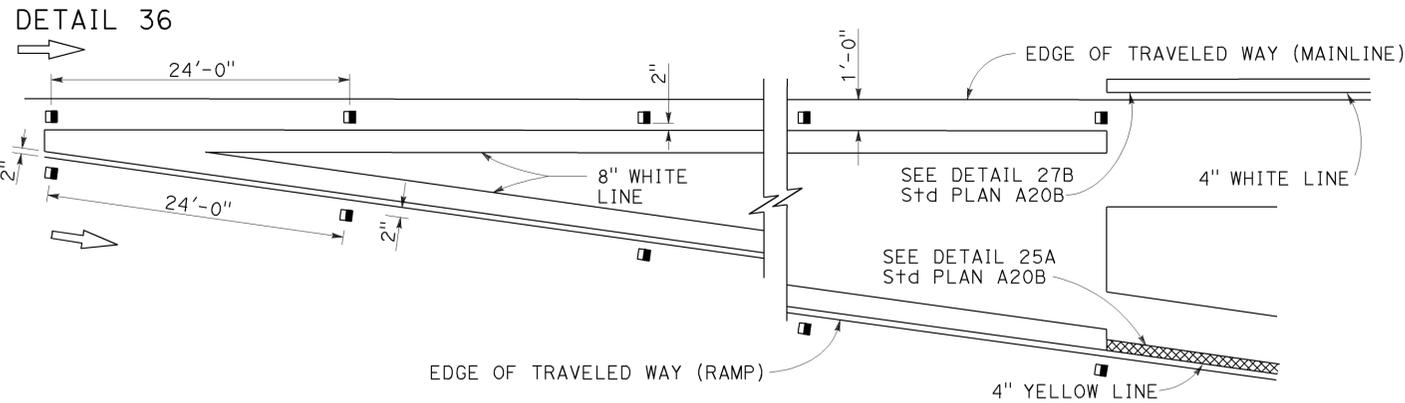

ENTRANCE RAMP NEUTRAL AREA (MERGE) TREATMENT

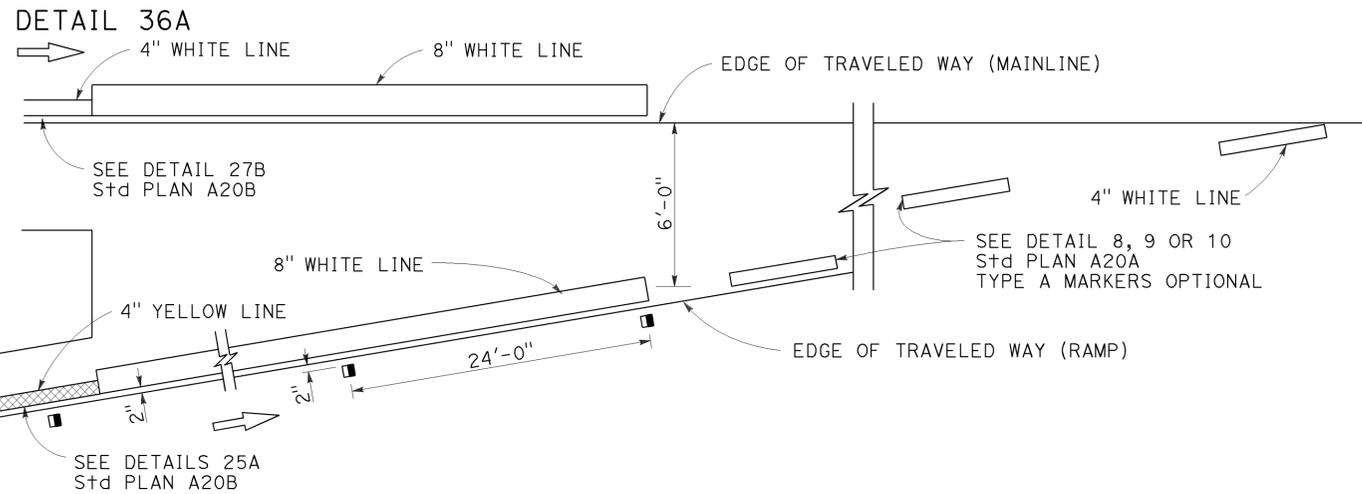

ENTRANCE RAMP NEUTRAL AREA (ACCELERATION LANE) TREATMENT

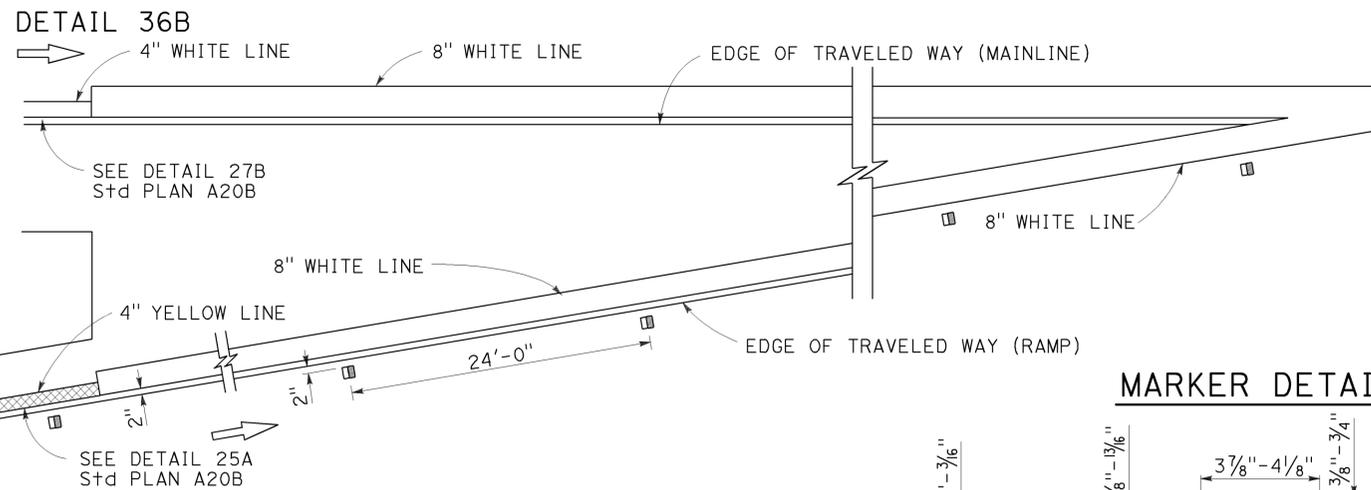


MARKER DETAILS

LEGEND:

MARKERS

- TYPE A WHITE NON-REFLECTIVE
- ◻ TYPE C RED-CLEAR RETROREFLECTIVE
- TYPE G ONE-WAY CLEAR RETROREFLECTIVE

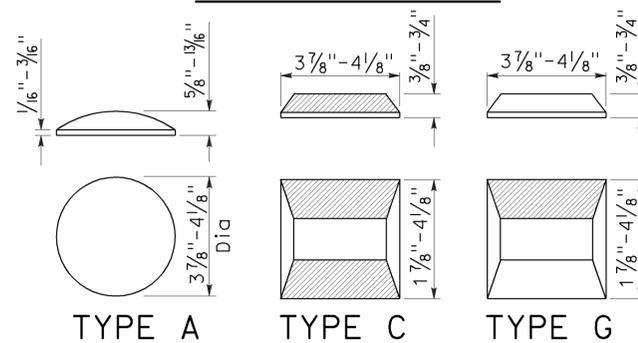

RETROREFLECTIVE FACE

Dist	COUNTY	ROUTE	POST MILES TOTAL PROJECT	SHEET No.	TOTAL SHEETS
03	ED, Sac, Yol	49, 50, 80	Var	14	25

Roberta L. McLaughlin
 REGISTERED CIVIL ENGINEER
 July 19, 2013
 PLANS APPROVAL DATE
THE STATE OF CALIFORNIA OR ITS OFFICERS OR AGENTS SHALL NOT BE RESPONSIBLE FOR THE ACCURACY OR COMPLETENESS OF SCANNED COPIES OF THIS PLAN SHEET.

REGISTERED PROFESSIONAL ENGINEER

Roberta L. McLaughlin

No. C40375



Exp. 3-31-15

CIVIL

STATE OF CALIFORNIA



TO ACCOMPANY PLANS DATED 1-27-15

LANE DROP AT EXIT RAMP

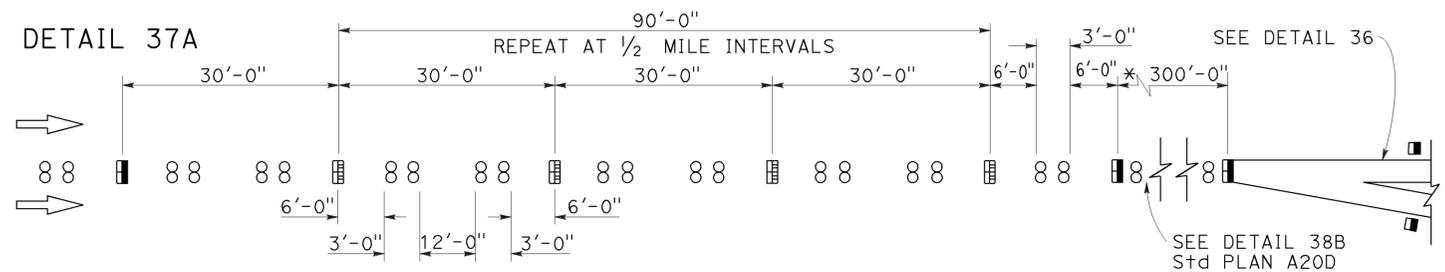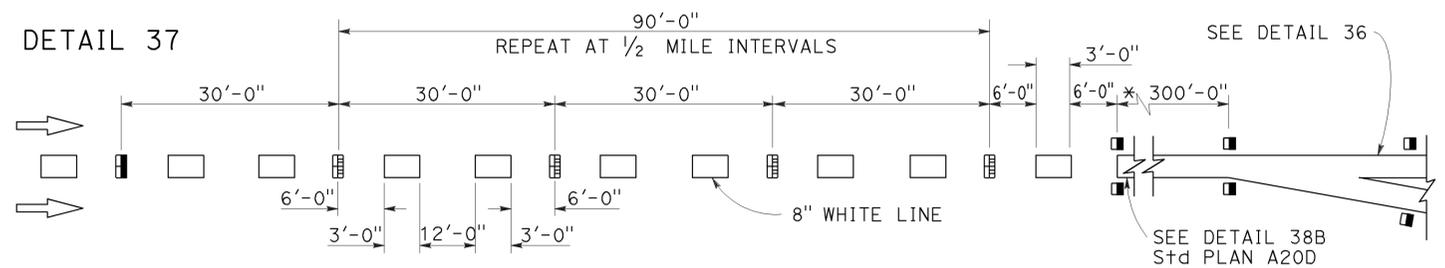

* The solid channelizing line shown may be omitted on short auxiliary lanes where weaving length is critical.

LANE DROP AT INTERSECTIONS

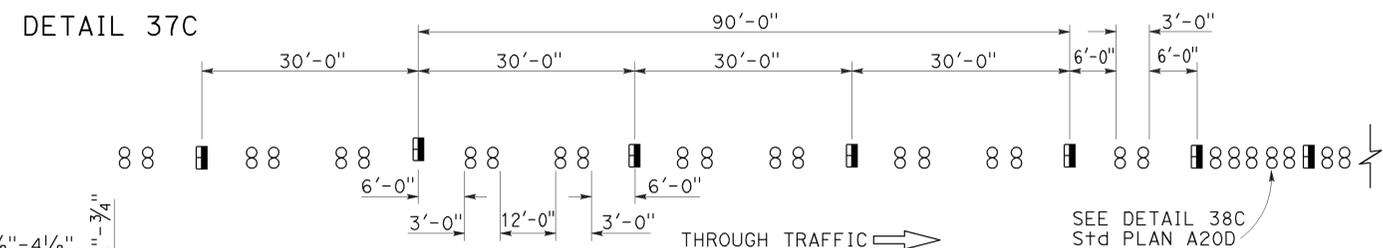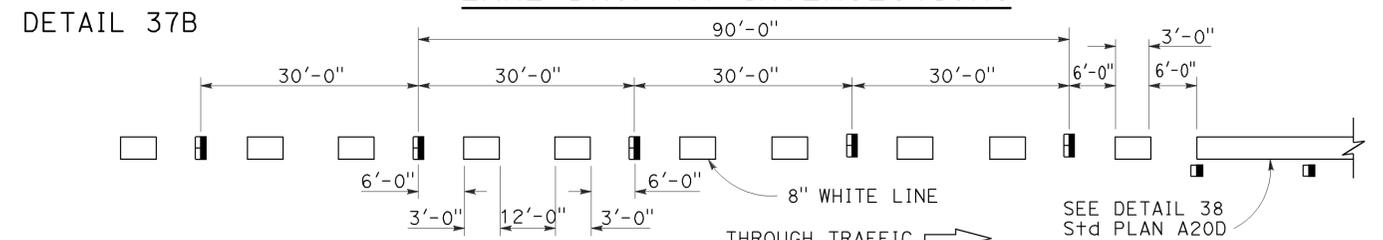

STATE OF CALIFORNIA
DEPARTMENT OF TRANSPORTATION

PAVEMENT MARKERS AND TRAFFIC LINE TYPICAL DETAILS

NO SCALE

RSP A20C DATED JULY 19, 2013 SUPERSEDES STANDARD PLAN A20C DATED MAY 20, 2011 - PAGE 11 OF THE STANDARD PLANS BOOK DATED 2010.

REVISED STANDARD PLAN RSP A20C

2010 REVISED STANDARD PLAN RSP A20C

Dist	COUNTY	ROUTE	POST MILES TOTAL PROJECT	SHEET No.	TOTAL SHEETS
03	ED, Sac, Yol	49, 50, 80	Var	15	25


Registered Professional Engineer
 Roberta L. McLaughlin
 No. C40375
 Exp. 3-31-13
 CIVIL
 STATE OF CALIFORNIA

July 20, 2012
 PLANS APPROVAL DATE


THE STATE OF CALIFORNIA OR ITS OFFICERS OR AGENTS SHALL NOT BE RESPONSIBLE FOR THE ACCURACY OR COMPLETENESS OF SCANNED COPIES OF THIS PLAN SHEET.

TO ACCOMPANY PLANS DATED 1-27-15


2010 REVISED STANDARD PLAN RSP A24E

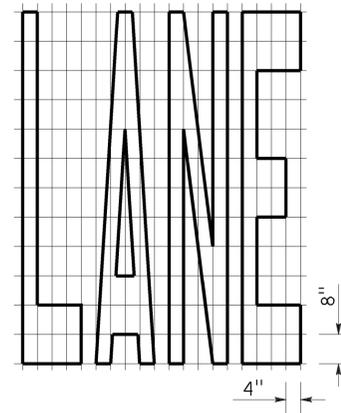


A=24 ft²

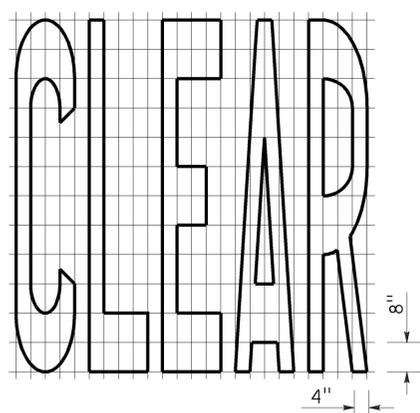


A=27 ft²

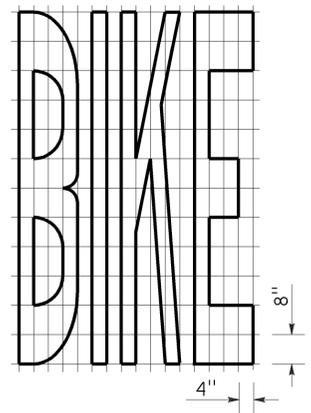


A=21 ft²

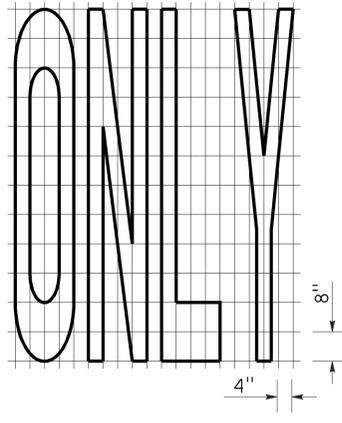


A=22 ft²

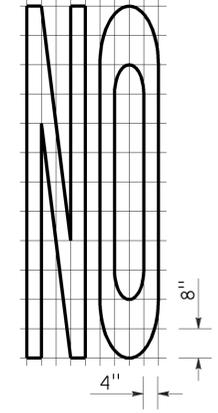


A=14 ft²

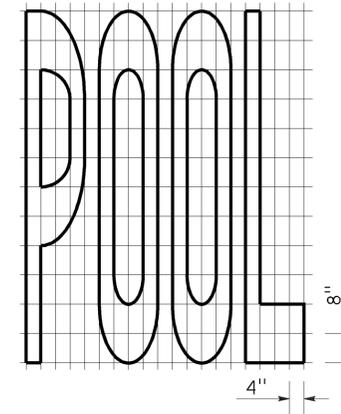


A=23 ft²

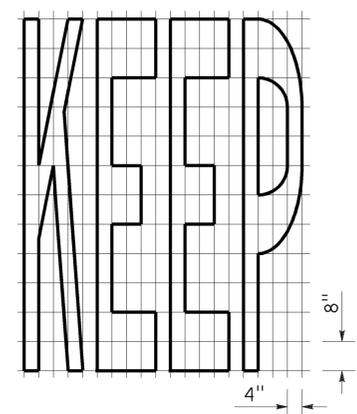


A=24 ft²

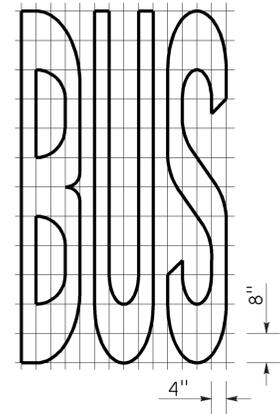

A=20 ft²


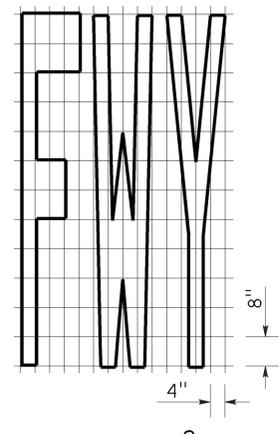


A=16 ft²

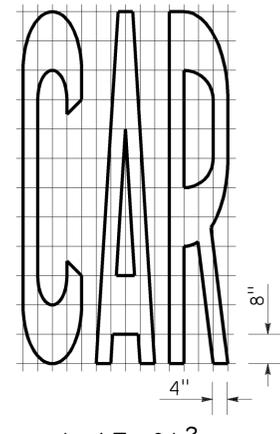


A=17 ft²

WORD MARKINGS			
ITEM	ft ²	ITEM	ft ²
LANE	24	NO	14
POOL	23	BIKE	21
CAR	17	BUS	20
CLEAR	27	ONLY	22
KEEP	24	FWY	16

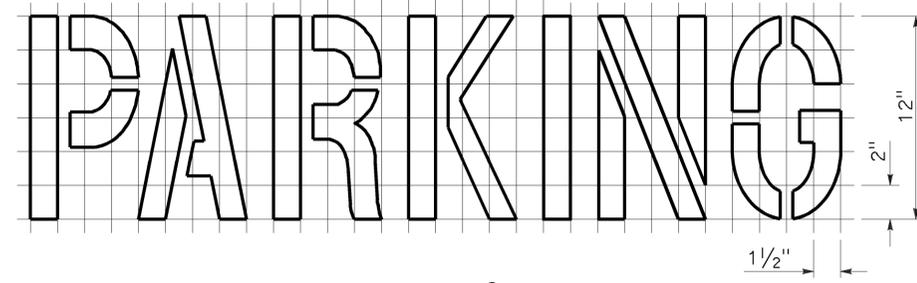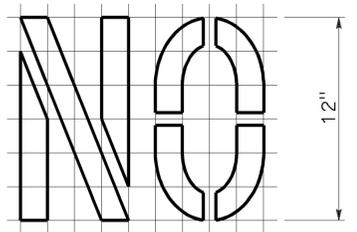

A=2 ft²
See Notes 6 and 7

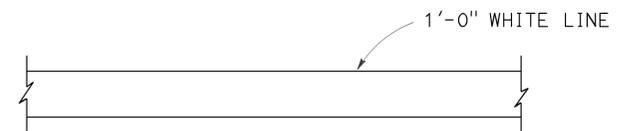

LIMIT LINE (STOP LINE)



↑
DIRECTION OF TRAVEL
YIELD LINE

NOTES:

1. If a message consists of more than one word, it should read "UP", i.e., the first word should be nearest the driver.
2. The space between words should be at least four times the height of the characters for low speed roads, but not more than ten times the height of the characters. The space may be reduced appropriately where there is limited space because of local conditions.
3. Minor variations in dimensions may be accepted by the Engineer.
4. Portions of a letter, number or symbol may be separated by connecting segments not to exceed 2" in width.
5. The words "NO PARKING" pavement marking is to be used for parking facilities. For typical locations of markings, see Standard Plans A90A and A90B.
6. The words "NO PARKING", shall be painted in white letters no less than 1'-0" high on a contrasting background and located so that it is visible to traffic enforcement officials.


STATE OF CALIFORNIA
DEPARTMENT OF TRANSPORTATION
**PAVEMENT MARKINGS
WORDS, LIMIT AND YIELD LINES**

NO SCALE

RSP A24E DATED JULY 20, 2012 SUPERSEDES STANDARD PLAN A24E
DATED MAY 20, 2011 - PAGE 17 OF THE STANDARD PLANS BOOK DATED 2010.

REVISED STANDARD PLAN RSP A24E

Dist	COUNTY	ROUTE	POST MILES TOTAL PROJECT	SHEET No.	TOTAL SHEETS
03	ED, Sac, Yol	49, 50, 80	Var	16	25

 
 REGISTERED CIVIL ENGINEER
 July 19, 2013
 PLANS APPROVAL DATE



THE STATE OF CALIFORNIA OR ITS OFFICERS OR AGENTS SHALL NOT BE RESPONSIBLE FOR THE ACCURACY OR COMPLETENESS OF SCANNED COPIES OF THIS PLAN SHEET.

TO ACCOMPANY PLANS DATED 1-27-15

TABLE 1

TAPER LENGTH CRITERIA AND CHANNELIZING DEVICE SPACING							
SPEED (S)	MINIMUM TAPER LENGTH * FOR WIDTH OF OFFSET 12 FEET (W)				MAXIMUM CHANNELIZING DEVICE SPACING		
	TANGENT 2L	MERGING L	SHIFTING L/2	SHOULDER L/3	X	Y	Z **
					TAPER	TANGENT	CONFLICT
mph	ft	ft	ft	ft	ft	ft	ft
20	160	80	40	27	20	40	10
25	250	125	63	42	25	50	12
30	360	180	90	60	30	60	15
35	490	245	123	82	35	70	17
40	640	320	160	107	40	80	20
45	1080	540	270	180	45	90	22
50	1200	600	300	200	50	100	25
55	1320	660	330	220	55	110	27
60	1440	720	360	240	60	120	30
65	1560	780	390	260	65	130	32
70	1680	840	420	280	70	140	35

* - For other offsets, use the following merging taper length formula for L:
 For speed of 40 mph or less, $L = WS^2/60$
 For speed of 45 mph or more, $L = WS$

Where: L = Taper length in feet
 W = Width of offset in feet
 S = Posted speed limit, off-peak 85th-percentile speed prior to work starting, or the anticipated operating speed in mph

** - Use for taper and tangent sections where there are no pavement markings or where there is a conflict between existing pavement markings and channelizers (CA).

TABLE 2

LONGITUDINAL BUFFER SPACE AND FLAGGER STATION SPACING				
SPEED *	Min D **	DOWNGRADE Min D ***		
		-3%	-6%	-9%
		ft	ft	ft
mph	ft	ft	ft	ft
20	115	116	120	126
25	155	158	165	173
30	200	205	215	227
35	250	257	271	287
40	305	315	333	354
45	360	378	400	427
50	425	446	474	507
55	495	520	553	593
60	570	598	638	686
65	645	682	728	785
70	730	771	825	891

* - Speed is posted speed limit, off-peak 85th-percentile speed prior to work starting, or the anticipated operating speed in mph

** - Longitudinal buffer space or flagger station spacing

*** - Use on sustained downgrade steeper than -3 percent and longer than 1 mile.

TABLE 3

ADVANCE WARNING SIGN SPACING			
ROAD TYPE	DISTANCE BETWEEN SIGNS *		
	A	B	C
	ft	ft	ft
URBAN - 25 mph OR LESS	100	100	100
URBAN - MORE THAN 25 mph TO 40 mph	250	250	250
URBAN - MORE THAN 40 mph	350	350	350
RURAL	500	500	500
EXPRESSWAY / FREEWAY	1000	1500	2640

* - The distances are approximate, are intended for guidance purposes only, and should be applied with engineering judgment. These distances should be adjusted by the Engineer for field conditions, if necessary, by increasing or decreasing the recommended distances.

STATE OF CALIFORNIA
 DEPARTMENT OF TRANSPORTATION

**TRAFFIC CONTROL SYSTEM TABLES
 FOR LANE AND RAMP CLOSURES**

NO SCALE

RSP T9 DATED JULY 19, 2013 SUPERSEDES RSP T9 DATED APRIL 19, 2013 THAT SUPPLEMENTS THE STANDARD PLANS BOOK DATED 2010.

REVISED STANDARD PLAN RSP T9


2010 REVISED STANDARD PLAN RSP T9

Dist	COUNTY	ROUTE	POST MILES TOTAL PROJECT	SHEET No.	TOTAL SHEETS
03	ED, Sac, Yol	49, 50, 80	Var	17	25

REGISTERED CIVIL ENGINEER
 April 19, 2013
 PLANS APPROVAL DATE

THE STATE OF CALIFORNIA OR ITS OFFICERS OR AGENTS SHALL NOT BE RESPONSIBLE FOR THE ACCURACY OR COMPLETENESS OF SCANNED COPIES OF THIS PLAN SHEET.

REGISTERED PROFESSIONAL ENGINEER
 Gurinderpal Bhullar
 No. C48815
 Exp. 9-30-14
 CIVIL
 STATE OF CALIFORNIA

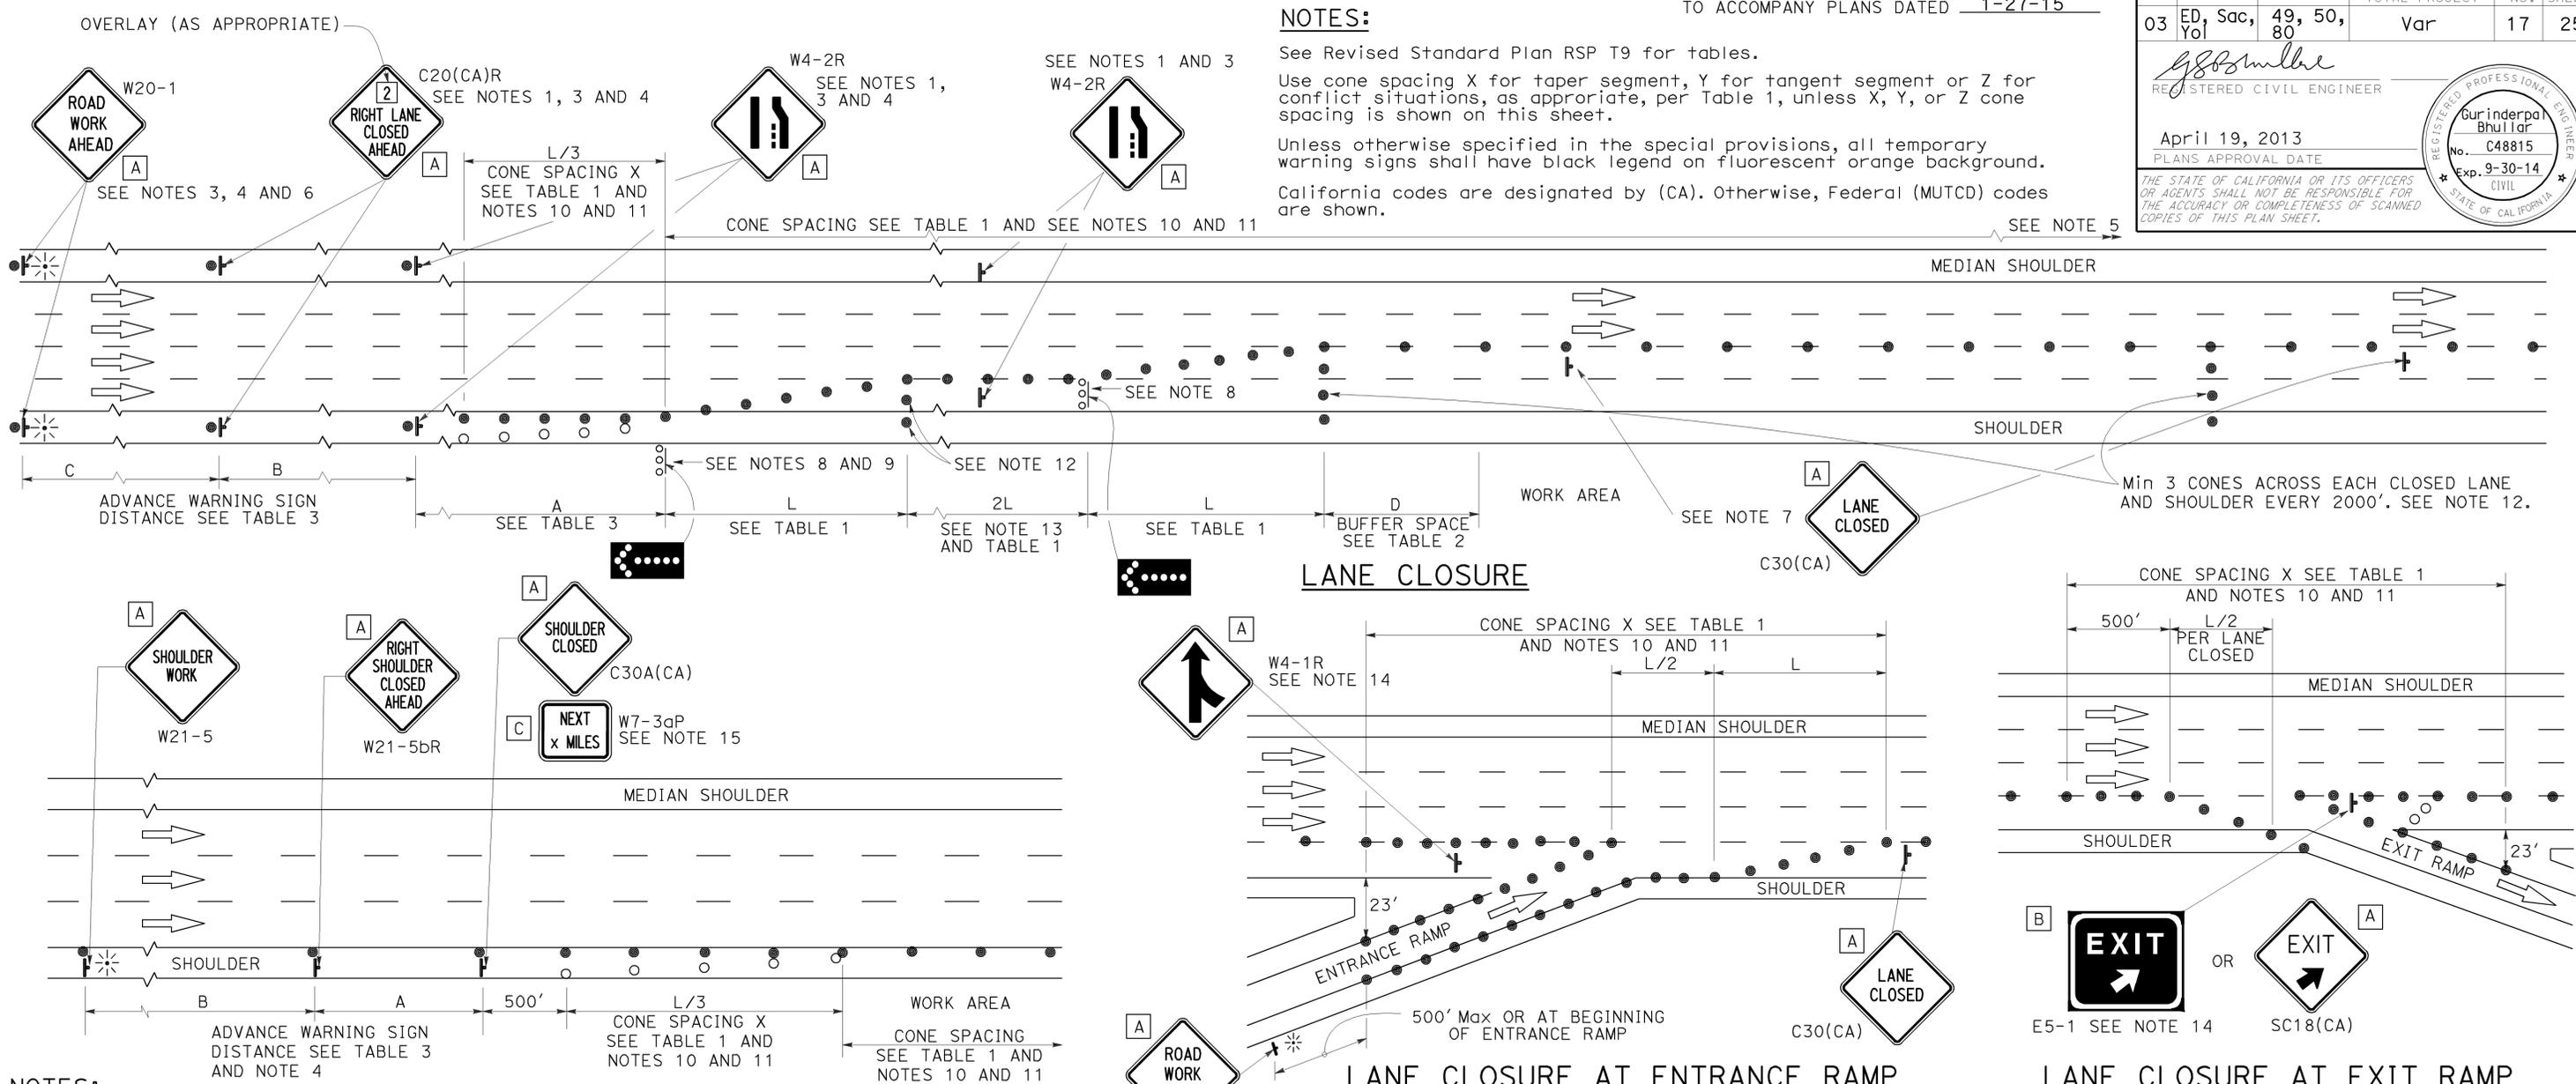

- NOTES:**
1. Median lane closures shall conform to the details as shown except that C20(CA)L and W4-2L signs shall be used.
 2. At least one person shall be assigned to provide full time maintenance of traffic control devices for lane closures.
 3. Duplicate sign installations are not required:
 - a) On opposite shoulder if at least one-half of the available lanes remain open to traffic.
 - b) In the median if the width of the median shoulder is less than 8' and the outside lanes are to be closed.
 4. Each advance warning sign on each side of the roadway shall be equipped with at least two flags for daytime closure. Each flag shall be at least 16" x 16" in size and shall be orange or fluorescent red-orange in color. Flashing beacons shall be placed at the locations indicated for lane closure during hours of darkness.
 5. A G20-2 "END ROAD WORK" sign, with minimum size of 48" x 24" as appropriate, shall be placed at the end of the lane closure unless the end of work area is obvious or ends within a larger project's limits.

- SHOULDER CLOSURE**
6. If the W20-1 sign would follow within 2000' of a stationary W20-1 or G20-1 "ROAD WORK NEXT x MILES", use a C20(CA) sign for the first advance warning sign.
 7. Place a C30(CA) sign every 2000' throughout length of lane closure.
 8. One flashing arrow sign for each lane closed. The flashing arrow signs shall be Type I.
 9. A minimum 1500' of sight distance shall be provided where possible for vehicles approaching the first flashing arrow sign. Lane closures shall not begin at top of crest vertical curve or on a horizontal curve.
 10. All cones used for lane closures during the hours of darkness shall be fitted with retroreflective bands (or sleeves) as specified in the specifications.
 11. Portable delineators, placed at one-half the spacing indicated for traffic cones may be used instead of cones for daytime closures only.

- LANE CLOSURE AT ENTRANCE RAMP**
12. Unless otherwise specified in the special provisions, a minimum of 3 cones shall be placed transversely across each closed lane and shoulder at each location where a taper across a traffic lane ends and every 2000' as shown on the "Lane Closure" detail. Two Type II barricades may be used instead of the 3 cones. The transverse alignment of the cones or barricades on the closed shoulder may be shifted from the transverse alignment to provide access to the work.
 13. Unless otherwise specified in the special provisions, the 2L tangent shown along lane lines shall be used between the L tapers required for each closed traffic lane.
 14. Unless otherwise specified in the special provisions, the E5-1 or SC18(CA) and W4-1 signs shall be used as shown.
 15. A W7-3aP "NEXT x MILES" plaque must be used if the shoulder closure extends beyond the distance that can be perceived by road users.

LEGEND

- TRAFFIC CONE
- TRAFFIC CONE (OPTIONAL TAPER)
- † TEMPORARY TRAFFIC CONTROL SIGN
- ⬢ FLASHING ARROW SIGN (FAS)
- ⬢ FAS SUPPORT OR TRAILER
- ☼ PORTABLE FLASHING BEACON

SIGN PANEL SIZE (Min)

A	48" x 48"
B	72" x 60"
C	36" x 30"

STATE OF CALIFORNIA
 DEPARTMENT OF TRANSPORTATION

**TRAFFIC CONTROL SYSTEM
 FOR LANE CLOSURE ON
 FREEWAYS AND EXPRESSWAYS**

NO SCALE

RSP T10 DATED APRIL 19, 2013 SUPERSEDES STANDARD PLAN T10 DATED MAY 20, 2011 - PAGE 237 OF THE STANDARD PLANS BOOK DATED 2010.

REVISED STANDARD PLAN RSP T10

2010 REVISED STANDARD PLAN RSP T10

NOTES:

See Revised Standard Plan RSP T9 for tables.


Use cone spacing X for taper segment, Y for tangent segment or Z for conflict situations, as appropriate, per Table 1, unless X, Y, or Z cone spacing is shown on this sheet.

Unless otherwise specified in the special provisions, all temporary warning signs shall have black legend on fluorescent orange background.

California codes are designated by (CA). Otherwise, Federal (MUTCD) codes are shown.


TYPICAL LANE CLOSURE WITH REVERSIBLE CONTROL

TO ACCOMPANY PLANS DATED 1-27-15

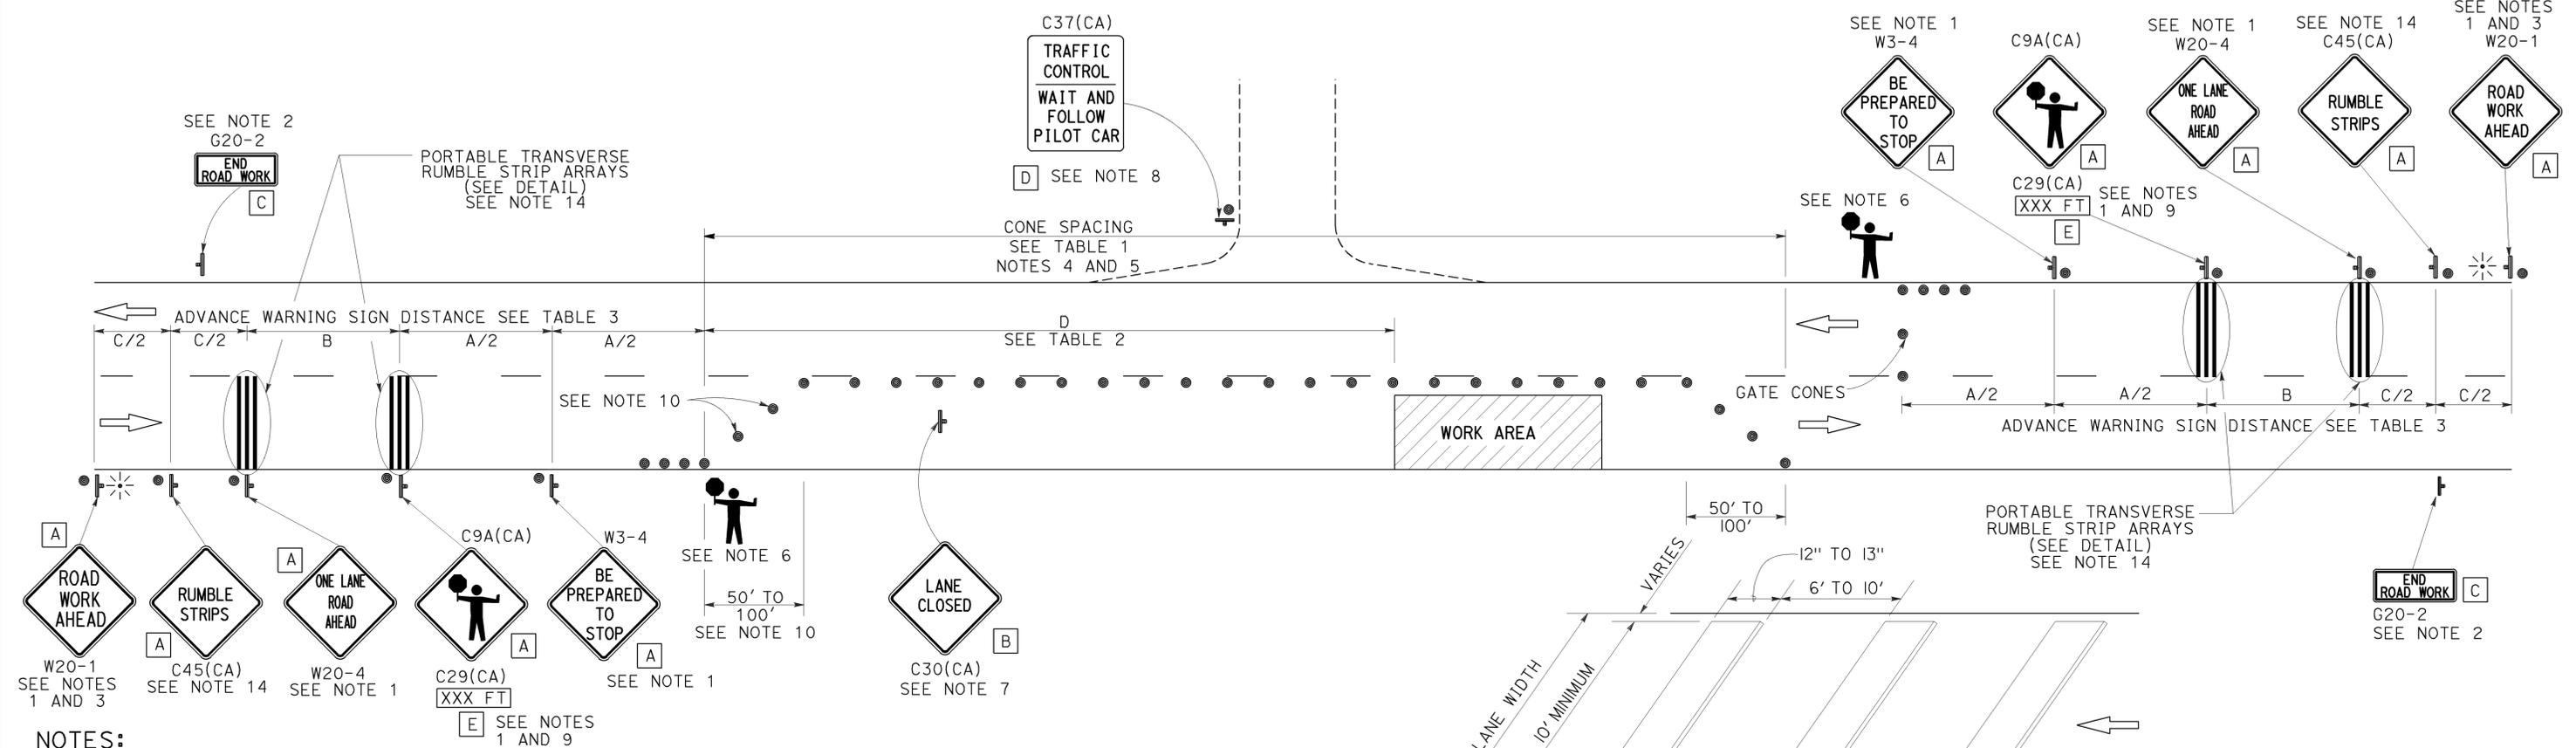

- NOTES:**
- Each advance warning sign in each direction of travel shall be equipped with at least two flags for daytime closure. Each flag shall be at least 16" x 16" in size and shall be orange or fluorescent red-orange in color. Flashing beacons shall be placed at the locations indicated for lane closure during hours of darkness.
 - A G20-2 "END ROAD WORK" sign, as appropriate, shall be placed at the end of the lane control unless the end of work area is obvious, or ends within a larger project's limits.
 - If the W20-1 sign would follow within 2000' of a stationary W20-1 or G20-1 "ROAD WORK NEXT _____ MILES", use a W20-4 sign for the first advance warning sign.
 - All cones used for lane closures during the hours of darkness shall be fitted with retroreflective bands (or sleeves) as specified in the specifications.
 - Portable delineators, placed at one-half the spacing indicated for traffic cones, may be used instead of cones for daytime closures only.
 - Additional advance flaggers may be required. Flagger should stand in a conspicuous place, be visible to approaching traffic as well as approaching vehicles after the first vehicle has stopped. During the hours of darkness, the flagging-station and flagger shall be illuminated and clearly visible to approaching traffic. The illumination footprint of the lighting on the ground shall be at least 20' in diameter. Place a minimum of four cones at 50' intervals in advance of flagger station as shown.

- Place C30(CA) "LANE CLOSED" sign at 500' to 1000' intervals throughout extended work areas. They are optional if the work area is visible from the flagger station.
- When a pilot car is used, place a C37(CA) "TRAFFIC CONTROL-WAIT AND FOLLOW PILOT CAR" sign with black legend on white background at all intersections, driveways and alleys without a flagger within traffic control area. Signs shall be clean and visible at all times. Where traffic can not be effectively self-regulated, at least one flagger shall be used at each intersection within traffic control area.
- An optional C29(CA) sign may be placed below the C9A(CA) sign.
- Either traffic cones or barricades shall be placed on the taper. Barricades shall be Type I, II, or III.
- The color of the portable transverse rumble strips shall be black or orange. Use 2 arrays, each array shall consist of 3 rumble strips.
- Portable transverse rumble strips shall not be placed on sharp horizontal or vertical curves nor shall they be placed through pedestrian crossings.
- If the portable transverse rumble strips become out of alignment (skewed) by more than 6 inches, measured from one end to the other, they shall be readjusted to bring the placement back to the original location.
- Portable transverse rumble strips are not required if any one of the following conditions is satisfied:
 - Work duration occupies a location for four hours or less
 - Posted speed limit is below 45 MPH
 - Work is of emergency nature
 - Work zone is in snow or icy weather conditions

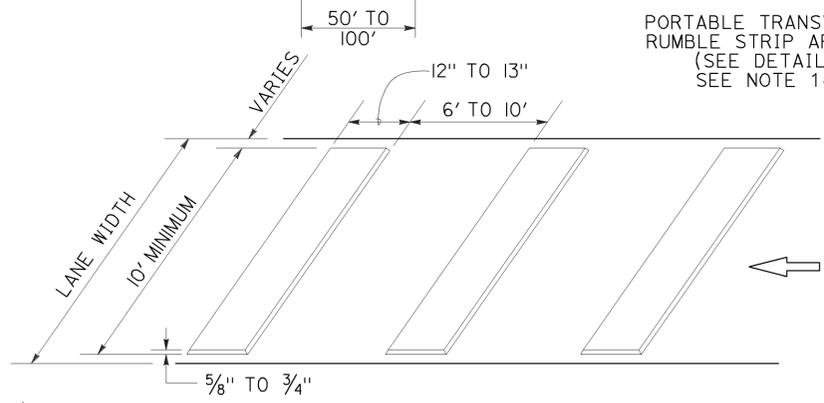

SIGN PANEL SIZE (Min)

- A 48" x 48"
- B 30" x 30"
- C 36" x 18"
- D 36" x 42"
- E 20" x 7"

LEGEND

- TRAFFIC CONE
- ⊥ TEMPORARY TRAFFIC CONTROL SIGN
- ⚡ PORTABLE FLASHING BEACON
- 🚧 FLAGGER

STATE OF CALIFORNIA
DEPARTMENT OF TRANSPORTATION

**TRAFFIC CONTROL SYSTEM
FOR LANE CLOSURE ON
TWO LANE CONVENTIONAL
HIGHWAYS**

NO SCALE

RSP T13 DATED OCTOBER 17, 2014 SUPERSEDES RSP T13 DATED JULY 18, 2014
AND RSP T13 DATED APRIL 19, 2013 AND STANDARD PLAN T13 DATED
MAY 20, 2011 - PAGE 241 OF THE STANDARD PLANS BOOK DATED 2010.

2010 REVISED STANDARD PLAN RSP T13

TYPICAL RAMP CLOSURES

SIGN PANEL SIZE (Min)

- A 48" x 48"
- B 48" x 30"
- C 36" x 36"
- D 48" x 36"

LEGEND

- TRAFFIC CONE
- † TEMPORARY TRAFFIC CONTROL SIGN
- ‡ BARRICADES
- ⚡ PORTABLE FLASHING BEACON

Dist	COUNTY	ROUTE	POST MILES TOTAL PROJECT	SHEET No.	TOTAL SHEETS
03	ED, Sac, Yol	49, 50, 80	Var	19	25

Gurinderpal Bhullar
 REGISTERED CIVIL ENGINEER
 April 19, 2013
 PLANS APPROVAL DATE


THE STATE OF CALIFORNIA OR ITS OFFICERS OR AGENTS SHALL NOT BE RESPONSIBLE FOR THE ACCURACY OR COMPLETENESS OF SCANNED COPIES OF THIS PLAN SHEET.

REGISTERED PROFESSIONAL ENGINEER
 Gurinderpal Bhullar
 No. C48815
 Exp. 9-30-14
 CIVIL
 STATE OF CALIFORNIA


TO ACCOMPANY PLANS DATED 1-27-15

NOTES:


- Barricades shall be Type I, II, or III for closures lasting one week or less and Type III for closures lasting longer than one week.
- In addition to placing the C19(CA) "RAMP CLOSED AHEAD" and C30(CA) "RAMP CLOSED" signs, black on orange overlay plates with the word "CLOSED" may be mounted, as directed by the Engineer, on all guide signs that refer to the closed ramp. The letter size on the overlay shall be the same as the guide sign.
- Each advance C19(CA) "RAMP CLOSED AHEAD" sign shall be equipped with at least two flags for daytime closure. Each flag shall be at least 16" x 16" in size and shall be orange or fluorescent red-orange in color. A flashing beacon shall be placed on top of the first C19(CA) sign during hours of darkness.
- All cones used for ramp closures during the hours of darkness shall be fitted with retroreflective bands (or sleeves) as specified in the specifications.
- Portable delineators, placed at one-half the spacing indicated for traffic cones, may be used instead of cones for daytime ramp closures only.
- At least one person shall be assigned to provide full time maintenance of traffic control devices, unless otherwise directed by the Engineer.
- The existing "EXIT" signs shall be covered during ramp closures.
- A minimum of 3 cones shall be placed transversely across each closed lane and shoulder.

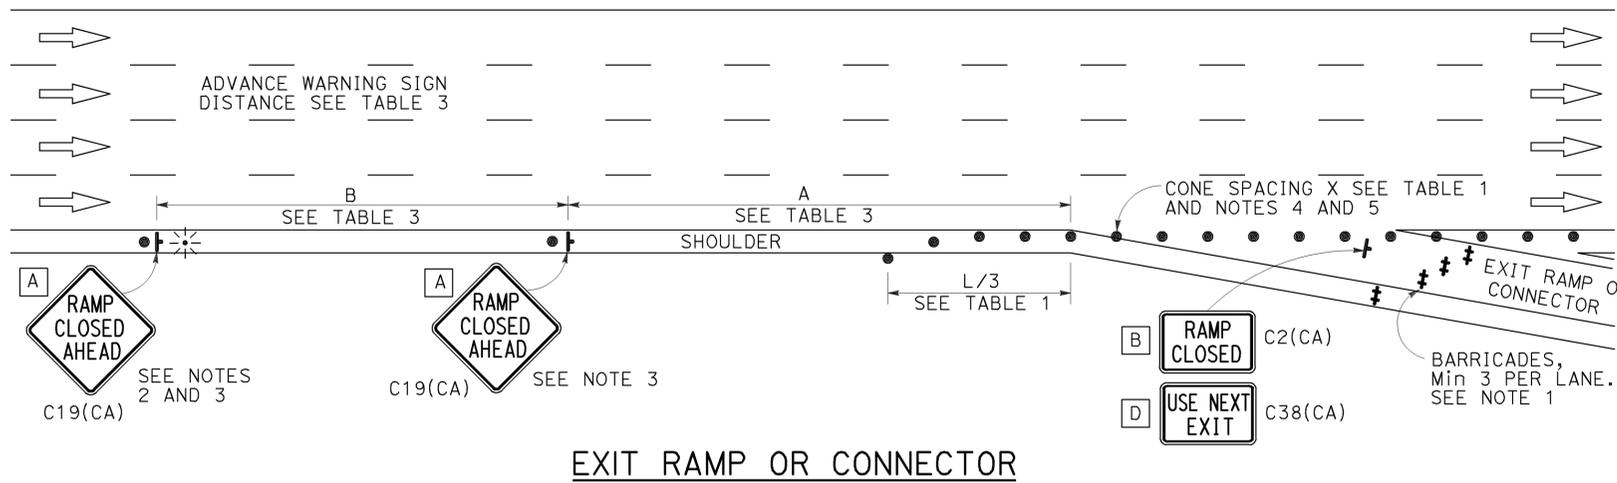


EXIT RAMP OR CONNECTOR

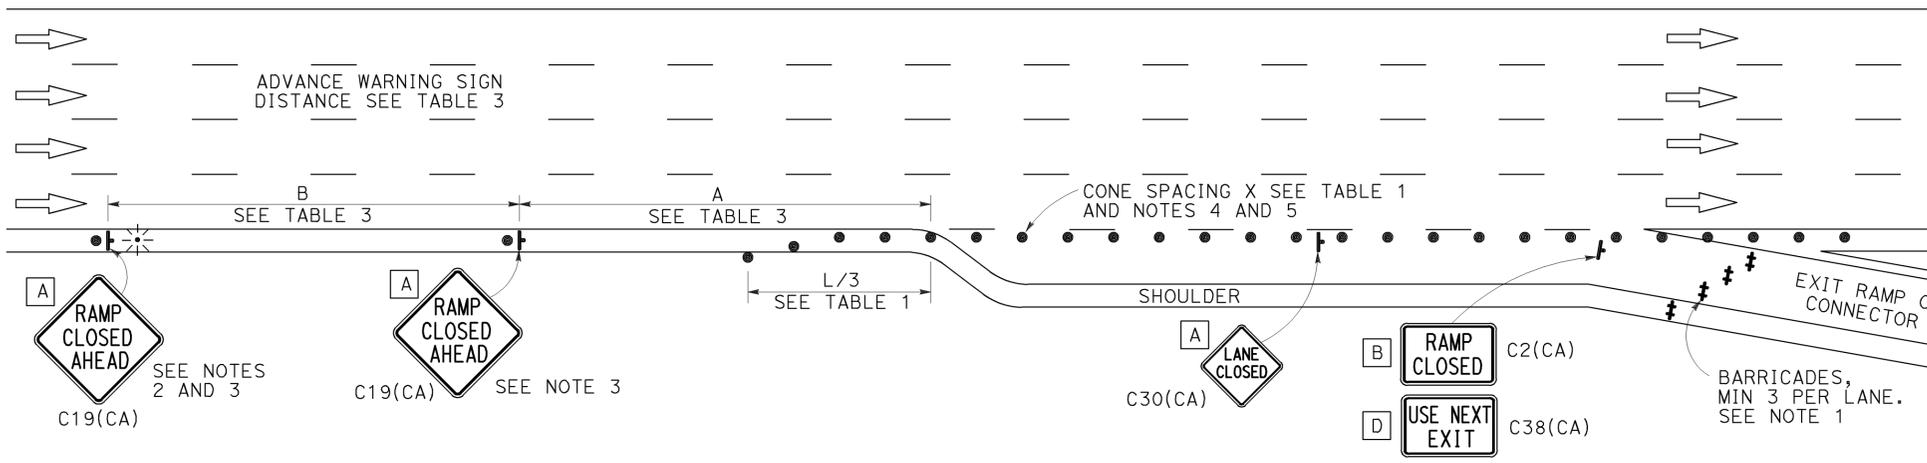

EXIT RAMP OR CONNECTOR WITH ADDITIONAL LANE

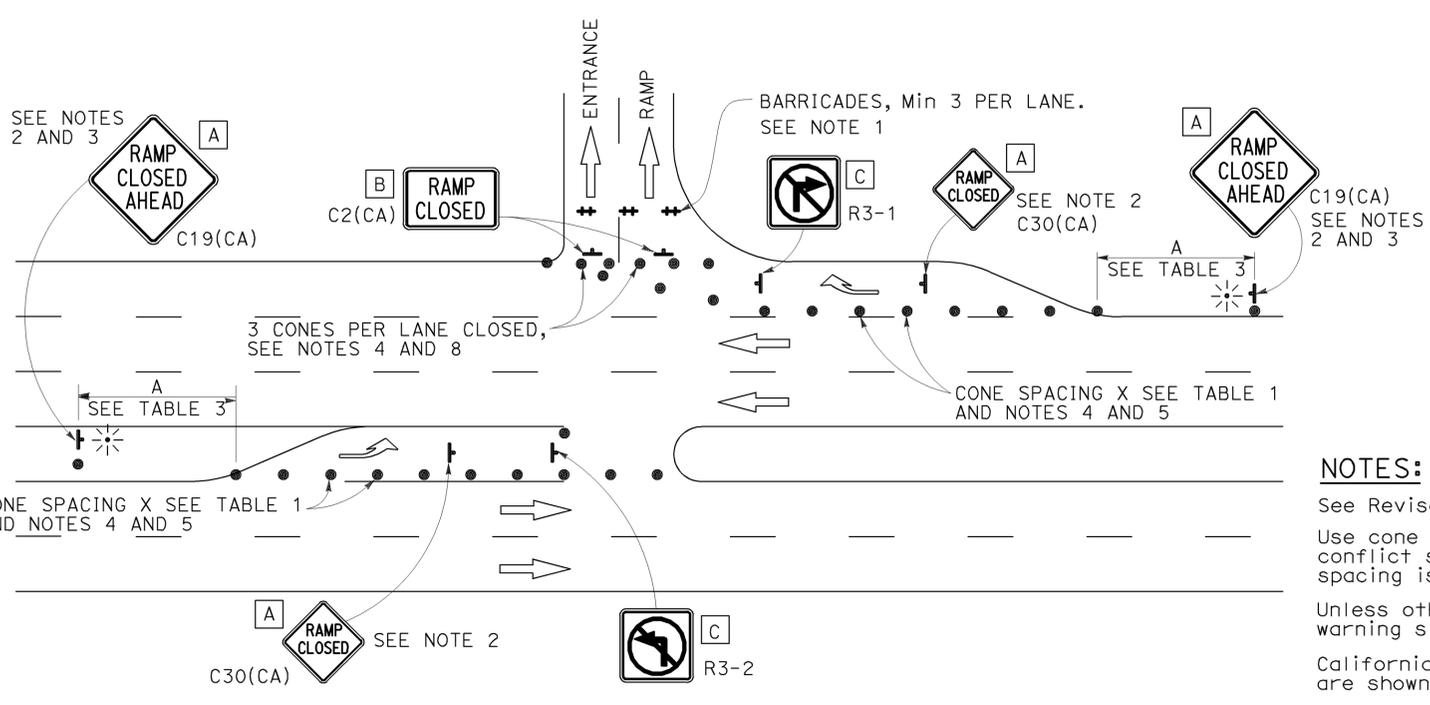

ENTRANCE RAMP WITH TURNING POCKETS

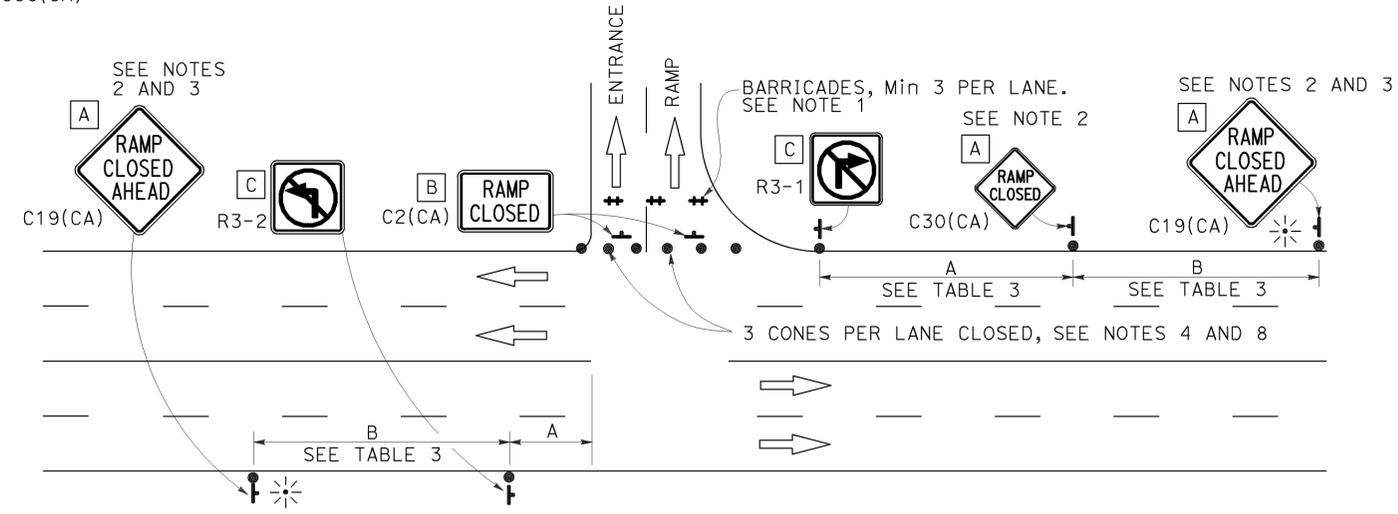

ENTRANCE RAMP WITHOUT TURNING POCKETS

NOTES:

- See Revised Standard Plan RSP T9 for tables.
- Use cone spacing X for taper segment, Y for tangent segment or Z for conflict situations, as appropriate, per Table 1, unless X, Y, or Z cone spacing is shown on this sheet.
- Unless otherwise specified in the special provisions, all temporary warning signs shall have black legend on fluorescent orange background.
- California codes are designated by (CA). Otherwise, Federal (MUTCD) codes are shown.

STATE OF CALIFORNIA
 DEPARTMENT OF TRANSPORTATION
**TRAFFIC CONTROL SYSTEM
 FOR RAMP CLOSURE**
 NO SCALE

RSP T14 DATED APRIL 19, 2013 SUPERSEDES STANDARD PLAN T14
 DATED MAY 20, 2011 - PAGE 242 OF THE STANDARD PLANS BOOK DATED 2010.

REVISED STANDARD PLAN RSP T14


2010 REVISED STANDARD PLAN RSP T14

LEGEND:

AB	ABANDON. IF APPLIED TO CONDUIT, REMOVE CONDUCTORS
BC	INSTALL PULL BOX IN EXISTING CONDUIT RUN
BP	PEDESTRIAN BARRICADE, TYPE AS INDICATED ON PLAN
CB	INSTALL CONDUIT INTO EXISTING PULL BOX
CC	CONNECT NEW AND EXISTING CONDUIT. REMOVE EXISTING CONDUCTORS AND INSTALL CONDUCTORS AS INDICATED
CF	CONDUIT TO REMAIN FOR FUTURE USE. REMOVE CONDUCTORS. INSTALL PULL TAPE
DH	DETECTOR HANDHOLE
FA	FOUNDATION TO BE ABANDONED
IS	INSTALL SIGN ON SIGNAL MAST ARM
NS	NO SLIP BASE ON STANDARD
PEC	PHOTOELECTRIC CONTROL
PEU	PHOTOELECTRIC UNIT
RC	EQUIPMENT OR MATERIAL TO BE REMOVED AND BECOME THE PROPERTY OF THE CONTRACTOR
RE	REMOVE ELECTROLIER, FUSES AND BALLAST. TAPE ENDS OF CONDUCTORS
RL	RELOCATE EQUIPMENT
RR	REMOVE AND REUSE EQUIPMENT
RS	REMOVE AND SALVAGE EQUIPMENT
SC	SPLICE NEW TO EXISTING CONDUCTORS
SD	SERVICE DISCONNECT
TSP	TELEPHONE SERVICE POINT

ABBREVIATIONS

APS	ACCESSIBLE PEDESTRIAN SIGNAL	M/M	MULTIPLE TO MULTIPLE TRANSFORMER
BBS	BATTERY BACKUP SYSTEM	Mtg	MOUNTING
BC	BOLT CIRCLE	MV	MERCURY VAPOR LIGHTING FIXTURE
BPB	BICYCLE PUSH BUTTON	MVDS	MICROWAVE VEHICLE DETECTION SYSTEM
C	CONDUIT	N	NEUTRAL (GROUNDED CONDUCTOR)
CB	CIRCUIT BREAKER	NB	NEUTRAL BUS
CCTV	CLOSED CIRCUIT TELEVISION	NC	NORMALLY CLOSE
Ck+	CIRCUIT	NO	NORMALLY OPEN
CMS	CHANGEABLE MESSAGE SIGN	P	CIRCUIT BREAKER'S POLE
Ctid	CALTRANS IDENTIFICATION	PB	PULL BOX
Comm	COMMUNICATION	PBA	PUSH BUTTON ASSEMBLY
DLC	LOOP DETECTOR LEAD-IN CABLE	PEC	PHOTOELECTRIC CONTROL
EMS	EXTINGUISHABLE MESSAGE SIGN	Ped	PEDESTRIAN
EVUC	EMERGENCY VEHICLE UNIT CABLE	PEU	PHOTOELECTRIC UNIT
EVUD	EMERGENCY VEHICLE UNIT DETECTOR	PT	CONDUIT WITH PULL TAPE
FB	FLASHING BEACON	RE	RELOCATED EQUIPMENT
FBCA	FLASHING BEACON CONTROL ASSEMBLY	RM	RAMP METERING
FBS	FLASHING BEACON WITH SLIP BASE	RWIS	ROADSIDE WEATHER INFORMATION SYSTEM
FO	FIBER OPTIC	SB	SLIP BASE
G	EQUIPMENT GROUNDING CONDUCTOR	SIC	SIGNAL INTERCONNECT CABLE
GB	GROUND BUS	Sig	SIGNAL
GFCI	GROUND FAULT CIRCUIT INTERRUPTER	SMA	SIGNAL MAST ARM
HAR	HIGHWAY ADVISORY RADIO	SNS	STREET NAME SIGN
Hex	HEXAGONAL	SP	SERVICE POINT
HPS	HIGH PRESSURE SODIUM	TDC	TELEPHONE DEMARCATION CABINET
IISNS	INTERNALLY ILLUMINATED STREET NAME SIGN	TMS	TRAFFIC MONITORING STATION
ISL	INDUCTION SIGN LIGHTING	TOS	TRAFFIC OPERATIONS SYSTEM
LED	LIGHT EMITTING DIODE	Veh	VEHICLE
LMA	LUMINAIRE MAST ARM	VIVDS	VIDEO IMAGE VEHICLE DETECTION SYSTEM
LPS	LOW PRESSURE SODIUM	WIM	WEIGH-IN-MOTION
Ltg	LIGHTING	Xfmr	TRANSFORMER
Lum	LUMINAIRE		
M	METERED		
MAT	MAST ARM MOUNTING TOP ATTACHMENT		
MAS	MAST ARM MOUNTING SIDE ATTACHMENT		

 Dist	COUNTY	ROUTE	POST MILES TOTAL PROJECT	SHEET No.	TOTAL SHEETS
03	ED, Sac, Yol	49, 50, 80	Var	20	25
 REGISTERED ELECTRICAL ENGINEER Theresa Aziz Gabriel No. E15129 Exp. 6-30-14 ELECTRICAL STATE OF CALIFORNIA					
July 19, 2013 PLANS APPROVAL DATE					
THE STATE OF CALIFORNIA OR ITS OFFICERS OR AGENTS SHALL NOT BE RESPONSIBLE FOR THE ACCURACY OR COMPLETENESS OF SCANNED COPIES OF THIS PLAN SHEET.					

TO ACCOMPANY PLANS DATED 1-27-15

SOFFIT AND WALL MOUNTED LUMINAIRES

-  PENDANT, 70 W HPS UNLESS OTHERWISE SPECIFIED
-  FLUSH, 70 W HPS UNLESS OTHERWISE SPECIFIED
-  WALL SURFACE, 70 W HPS UNLESS OTHERWISE SPECIFIED
-  EXISTING SOFFIT OR WALL LUMINAIRE TO REMAIN UNMODIFIED
-  EXISTING SOFFIT OR WALL LUMINAIRE TO BE MODIFIED AS SPECIFIED

NOTE:
Arrow indicates "street side" of luminaire.

COMMONLY USED SYMBOLS FOR UNITED STATES CUSTOMARY UNITS OF MEASUREMENT:

SYMBOL USED	DEFINITIONS
Ω	OHMS
min	MINUTE
s	SECOND
bps	BITS PER SECOND
Bps	BYTES PER SECOND
A	AMPERE
V	VOLT
V(dc)	VOLT (DIRECT CURRENT)
V(ac)	VOLT (ALTERNATING CURRENT)
FC	FOOT - CANDLE
W	WATTS
VA	VOLT-AMPERE
M	MEGA
k	KILO
m	MILLI
μ	MICRO
P	PICO
HZ	HERTZ







MISCELLANEOUS ELECTROLIERS

NEW	EXISTING	
		LUMINAIRE ON WOOD POLE
		NON-STANDARD ELECTROLIER (SEE PROJECT NOTES OR PROJECT PLANS)
		CITY ELECTROLIER
		ELECTROLIER FOUNDATION (FUTURE INSTALLATION)

NOTES:

- HPS luminaires shall be 310 W HPS when installed on Type 21, 21D, 30, 31 and 32 Standards, unless otherwise specified. HPS luminaires shall be 200 W when installed on other type standards or poles, unless otherwise specified.
- LED luminaires shall be 235 W when installed on Type 21, 21D, 30, 31 and 32 Standards, unless otherwise specified. LED luminaires shall be 165 W when installed on other type standards or poles, unless otherwise specified.
- Luminaires shall be the cutoff type, ANSI Type III medium cutoff lighting distribution, unless otherwise specified.

      STANDARD ELECTROLIER

NEW	EXISTING	STANDARD TYPE
		15
		15D
		15 STRUCTURE
		15D STRUCTURE
		21
		21D
		21 STRUCTURE
		21D STRUCTURE
		30
		31
		32

STATE OF CALIFORNIA
DEPARTMENT OF TRANSPORTATION

ELECTRICAL SYSTEMS (LEGEND AND ABBREVIATIONS)

NO SCALE

RSP ES-1A DATED JULY 19, 2013 SUPERSEDES STANDARD PLAN ES-1A DATED MAY 20, 2011 - PAGE 425 OF THE STANDARD PLANS BOOK DATED 2010.

REVISED STANDARD PLAN RSP ES-1A

2010 REVISED STANDARD PLAN RSP ES-1A

Dist	COUNTY	ROUTE	POST MILES TOTAL PROJECT	SHEET No.	TOTAL SHEETS
03	ED, Sac, Yol	49, 50, 80	Var	21	25

Theresa Gabriel
REGISTERED ELECTRICAL ENGINEER

July 19, 2013
PLANS APPROVAL DATE

Theresa Aziz Gabriel
No. E15129
Exp. 6-30-14
ELECTRICAL
STATE OF CALIFORNIA

THE STATE OF CALIFORNIA OR ITS OFFICERS OR AGENTS SHALL NOT BE RESPONSIBLE FOR THE ACCURACY OR COMPLETENESS OF SCANNED COPIES OF THIS PLAN SHEET.

TO ACCOMPANY PLANS DATED 1-27-15

CONDUIT

SIGNAL EQUIPMENT

NEW	EXISTING	
---	---	LIGHTING CONDUIT, UNLESS OTHERWISE INDICATED OR NOTED
---	---	TRAFFIC SIGNAL CONDUIT
---C---	---c---	COMMUNICATION CONDUIT
---T---	---t---	TELEPHONE CONDUIT
---F---	---f---	FIRE ALARM CONDUIT
---FO---	---fo---	FIBER OPTIC CONDUIT
---	---	CONDUIT TERMINATION
		CONDUIT RISER ATTACHED TO THE STRUCTURE OR SERVICE POLE

NEW	EXISTING	
		PEDESTRIAN SIGNAL HEAD "C" INDICATES COUNTDOWN PEDESTRIAN HEAD
		PUSH BUTTON ASSEMBLY POST
		PEDESTRIAN BARRICADE
		VEHICLE SIGNAL HEAD (WITH BACKPLATE AND 3-SECTIONS: RED, YELLOW AND GREEN)
		VEHICLE SIGNAL HEAD WITH ANGLE VISOR
		MODIFICATIONS OF BASIC SYMBOL: "L" INDICATES ALL NON-ARROW SECTIONS LOUVERED "LG" INDICATES LOUVERED GREEN SECTION ONLY "PV" INDICATES ALL 12" SECTIONS PROGRAMMED VISIBILITY "8" INDICATES ALL 8" SECTIONS (ONLY WHEN SPECIFIED)

SIGNAL EQUIPMENT Cont

NEW	EXISTING	
		GUARD POST
		TYPE 1 STANDARD WITH RAMP METERING SIGN
		OPTICAL DETECTOR FOR THE EMERGENCY VEHICLE DETECTION SYSTEM

SERVICE EQUIPMENT


NEW	EXISTING	
---OH---	---oh---	OVERHEAD LINES
		WOOD POLE, "U" INDICATES UTILITY OWNED
		POLE GUY WITH ANCHOR
		UTILITY TRANSFORMER - GROUND MOUNTED
		SERVICE EQUIPMENT ENCLOSURE TYPE. DOOR INDICATES FRONT OF ENCLOSURE
		TELEPHONE DEMARCATION CABINET

		VEHICLE SIGNAL HEAD CONSISTING OF RED, YELLOW AND GREEN LEFT ARROW SECTIONS
		VEHICLE SIGNAL HEAD CONSISTING OF RED AND YELLOW SECTIONS WITH AN UP GREEN ARROW SECTION
		VEHICLE SIGNAL HEAD (5 SECTION) CONSISTING OF RED, YELLOW AND GREEN SECTIONS WITH YELLOW AND GREEN RIGHT ARROW SECTIONS
		TYPE 15TS STANDARD WITH VEHICLE SIGNAL HEAD AND LUMINAIRE
		TYPE 21TS STANDARD WITH VEHICLE SIGNAL HEAD AND LUMINAIRE
		STANDARD WITH LUMINAIRE AND SIGNAL MAST ARMS AND ATTACHED VEHICLE SIGNAL HEADS
		TYPE 1 STANDARD WITH ATTACHED VEHICLE SIGNAL HEADS
		STANDARD WITH A SIGNAL MAST ARM, ATTACHED VEHICLE SIGNAL HEADS AND INTERNALLY ILLUMINATED STREET NAME SIGN
		CONTROLLER ASSEMBLY. DOOR INDICATES FRONT OF CABINET

NOTES:

- All signal sections shall be 12" unless shown otherwise.
- Signal heads shall be provided with backplates unless shown otherwise.

 POLE-MOUNTED SERVICE DESIGNATION



FLASHING BEACON

NEW	EXISTING	
		FLASHING BEACON (ONE VEHICLE SIGNAL HEAD WITH BACKPLATE AND VISOR) "R" INDICATES RED INDICATION, "Y" INDICATES YELLOW INDICATION
		FLASHING BEACON WITH TYPE 15-FBS STANDARD AND A SIGN.
		FLASHING BEACON WITH TYPES 9, 9A OR 9B SIGN UNLESS OTHERWISE SPECIFIED OR INDICATED

ILLUMINATED OVERHEAD SIGN

NEW	EXISTING	
		SINGLE POST, SINGLE ILLUMINATED SIGN, BALANCED BUTTERFLY
		SINGLE POST, DOUBLE ILLUMINATED SIGN, BALANCED BUTTERFLY
		SINGLE POST, SINGLE ILLUMINATED SIGN, FULL CANTILEVER
		DOUBLE POST, SINGLE ILLUMINATED SIGN
		SINGLE ILLUMINATED SIGN MOUNTED ON STRUCTURE
		DOUBLE POST, SINGLE ILLUMINATED SIGN WITH ELECTROLIER

STATE OF CALIFORNIA
DEPARTMENT OF TRANSPORTATION
**ELECTRICAL SYSTEMS
(LEGEND AND ABBREVIATIONS)**

NO SCALE


RSP ES-1B DATED JULY 19, 2013 SUPERSEDES STANDARD PLAN ES-1B DATED MAY 20, 2011 - PAGE 426 OF THE STANDARD PLANS BOOK DATED 2010.

REVISED STANDARD PLAN RSP ES-1B


2010 REVISED STANDARD PLAN RSP ES-1B

EQUIPMENT IDENTIFICATION


ILLUMINATED SIGN IDENTIFICATION NUMBER:

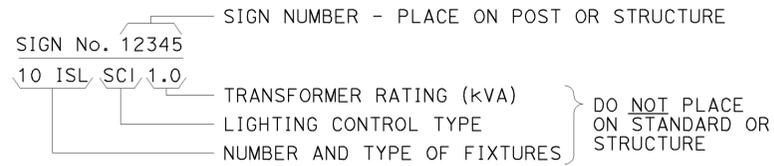


ELECTROLIER OR EQUIPMENT IDENTIFICATION NUMBER:

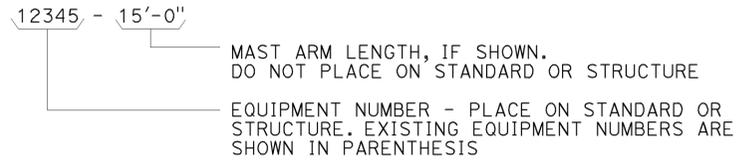


CONDUIT AND CONDUCTOR IDENTIFICATION:

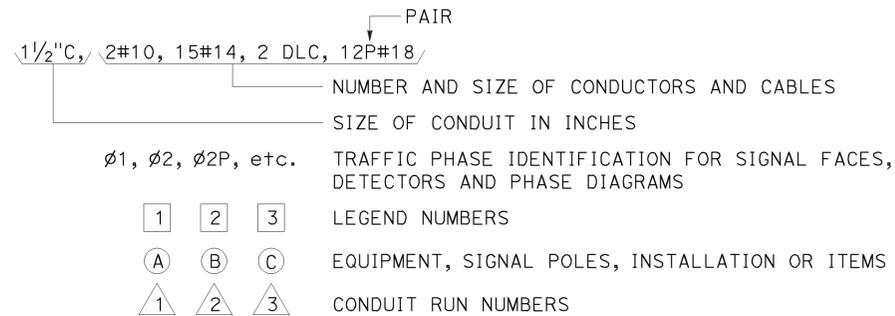


SIGNAL AND LIGHTING STANDARD (TYPICAL DESIGNATION):

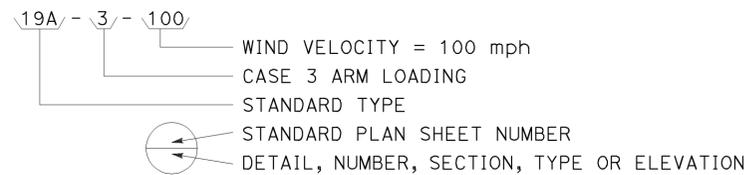


MISCELLANEOUS EQUIPMENT

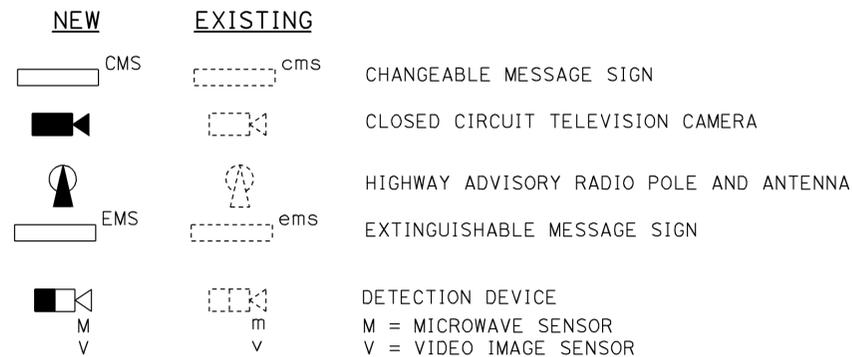



WIRING DIAGRAM LEGEND

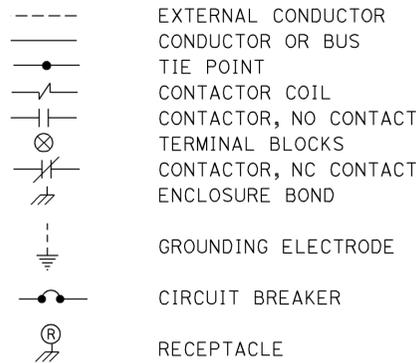

PULL BOXES

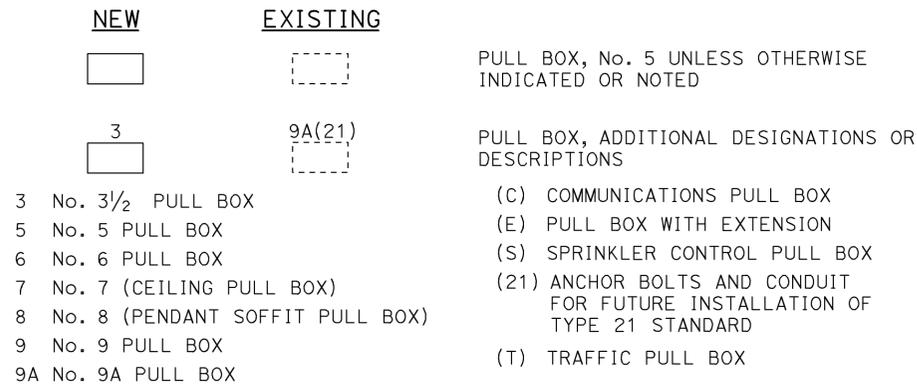

VEHICLE DETECTORS

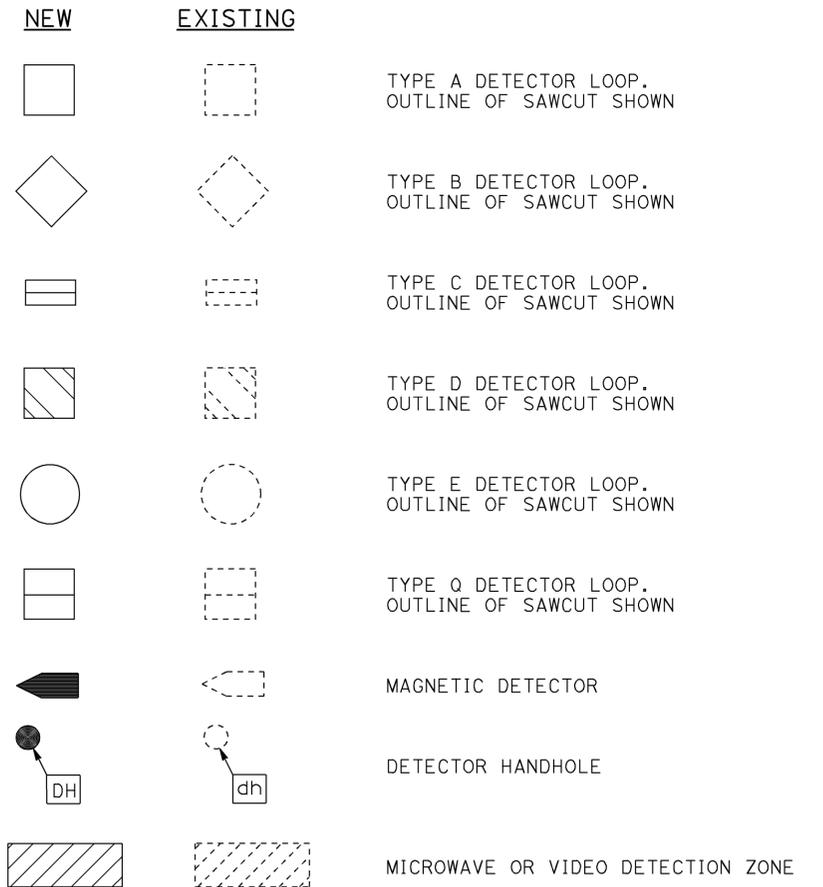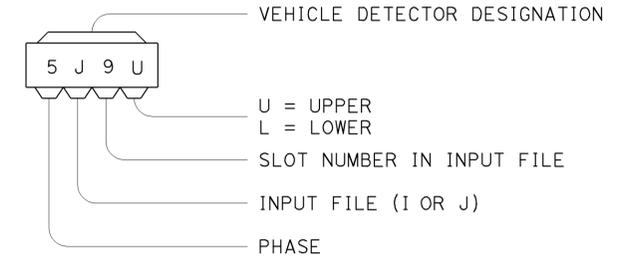

STATE OF CALIFORNIA
DEPARTMENT OF TRANSPORTATION

ELECTRICAL SYSTEMS (LEGEND AND ABBREVIATIONS)



NO SCALE

RSP ES-1C DATED JULY 19, 2013 SUPERSEDES STANDARD PLAN ES-1C
DATED MAY 20, 2011 - PAGE 427 OF THE STANDARD PLANS BOOK DATED 2010.


REVISED STANDARD PLAN RSP ES-1C

2010 REVISED STANDARD PLAN RSP ES-1C


Dist	COUNTY	ROUTE	POST MILES TOTAL PROJECT	SHEET No.	TOTAL SHEETS
03	ED, Sac, Yol	49, 50, 80	Var	23	25
<i>Theresa Gabriel</i> REGISTERED ELECTRICAL ENGINEER July 19, 2013 PLANS APPROVAL DATE <small>THE STATE OF CALIFORNIA OR ITS OFFICERS OR AGENTS SHALL NOT BE RESPONSIBLE FOR THE ACCURACY OR COMPLETENESS OF SCANNED COPIES OF THIS PLAN SHEET.</small>					
TO ACCOMPANY PLANS DATED <u>1-27-15</u>					

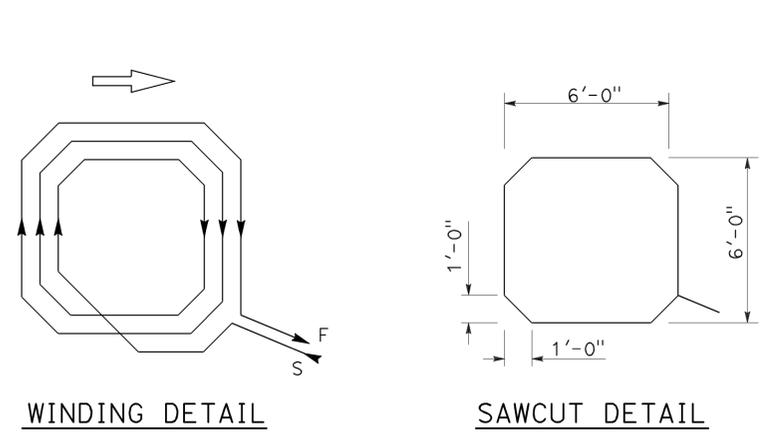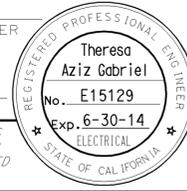


WINDING DETAIL
SAWCUT DETAIL
TYPE A LOOP DETECTOR CONFIGURATION

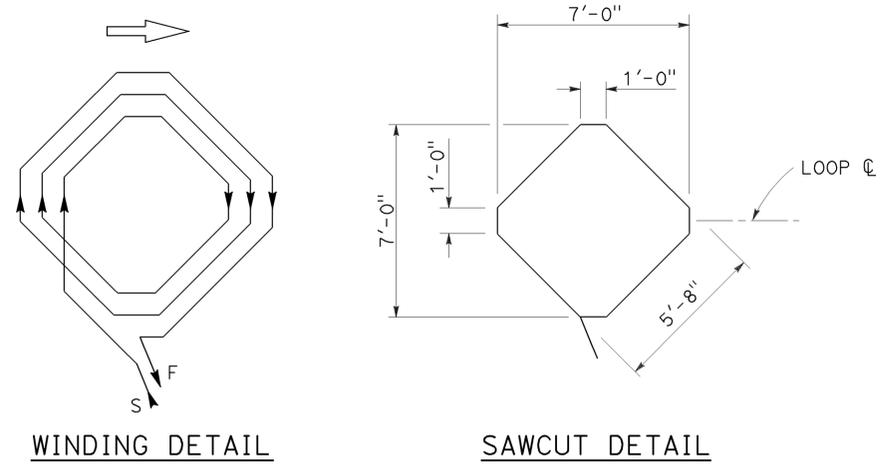


WINDING DETAIL
SAWCUT DETAIL
TYPE B LOOP DETECTOR CONFIGURATION

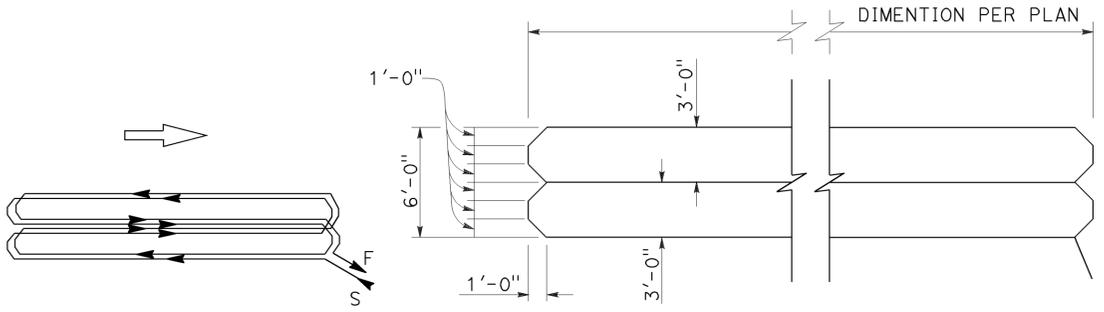


WINDING DETAIL
SAWCUT DETAIL
TYPE C LOOP DETECTOR CONFIGURATION

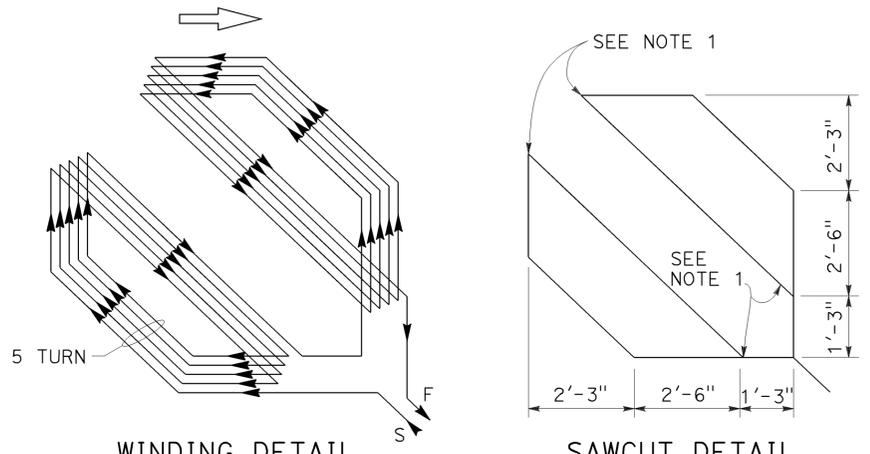


WINDING DETAIL
SAWCUT DETAIL
TYPE D LOOP DETECTOR CONFIGURATION

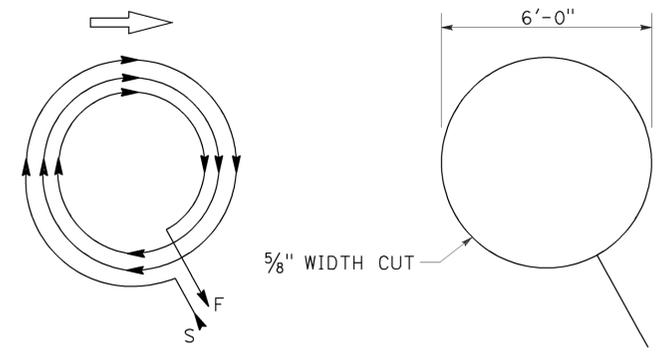

WINDING DETAIL
SAWCUT DETAIL
TYPE E LOOP DETECTOR CONFIGURATION

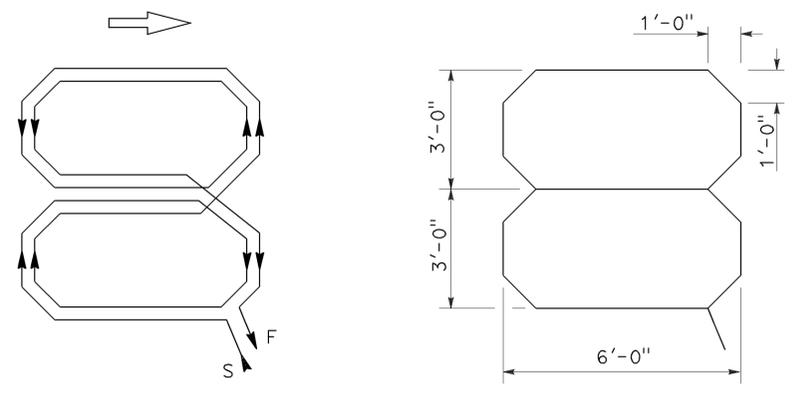

WINDING DETAIL
SAWCUT DETAIL
TYPE Q LOOP DETECTOR CONFIGURATION

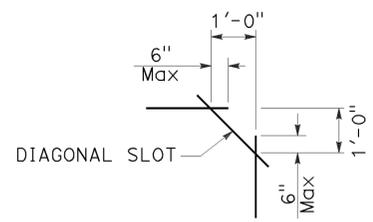

PLAN VIEW OF DIAGONAL SLOT AT CORNERS

- NOTES:**
1. Round corners of acute angle sawcuts to prevent damage to conductors.
 2. Typical distance separating loops from edge to edge is 10' for Type A, B, D and E installation in single lane.

STATE OF CALIFORNIA
DEPARTMENT OF TRANSPORTATION


ELECTRICAL SYSTEMS (DETECTORS)

NO SCALE


RSP ES-5B DATED JULY 19, 2013 SUPERSEDES STANDARD PLAN ES-5B DATED MAY 20, 2011 - PAGE 449 OF THE STANDARD PLANS BOOK DATED 2010.

2010 REVISED STANDARD PLAN RSP ES-5B


Dist	COUNTY	ROUTE	POST MILES TOTAL PROJECT	SHEET No.	TOTAL SHEETS
03	ED, Sac, Yol	49, 50, 80	Var	24	25
<i>Theresa Gabriel</i> REGISTERED ELECTRICAL ENGINEER July 19, 2013 PLANS APPROVAL DATE <small>THE STATE OF CALIFORNIA OR ITS OFFICERS OR AGENTS SHALL NOT BE RESPONSIBLE FOR THE ACCURACY OR COMPLETENESS OF SCANNED COPIES OF THIS PLAN SHEET.</small>					
TO ACCOMPANY PLANS DATED <u>1-27-15</u>					

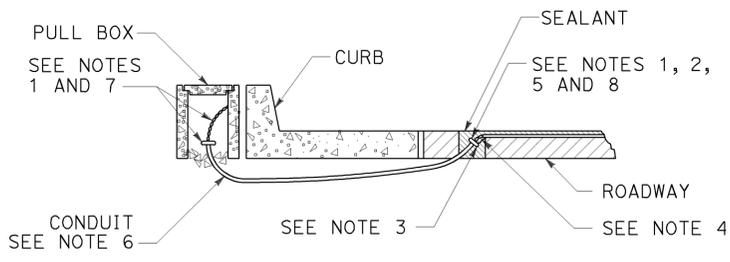


TYPE A
CURB TERMINATION DETAIL

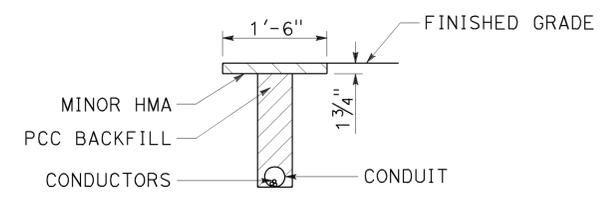


"T" TRENCH
DETAIL T

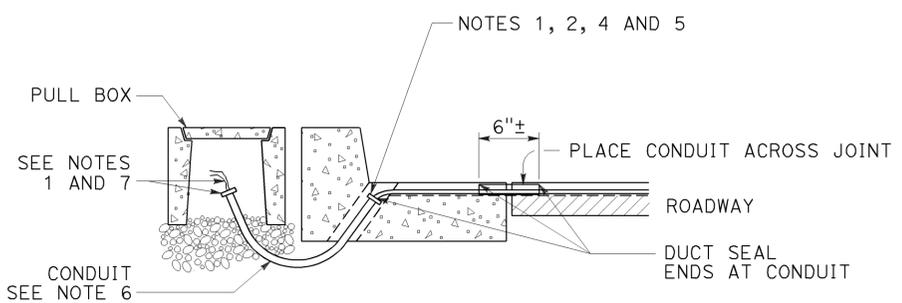

CROSS SECTION

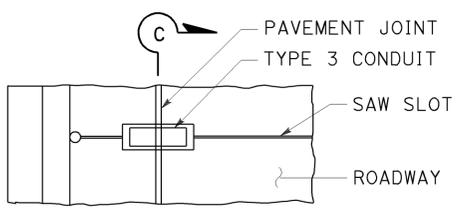


PLAN VIEW

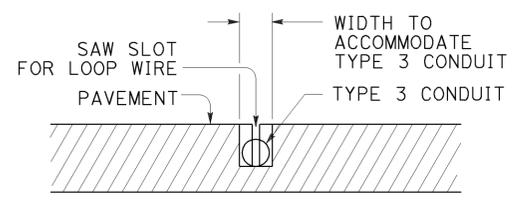


SECTION C-C


TYPE B
CURB TERMINATION DETAIL

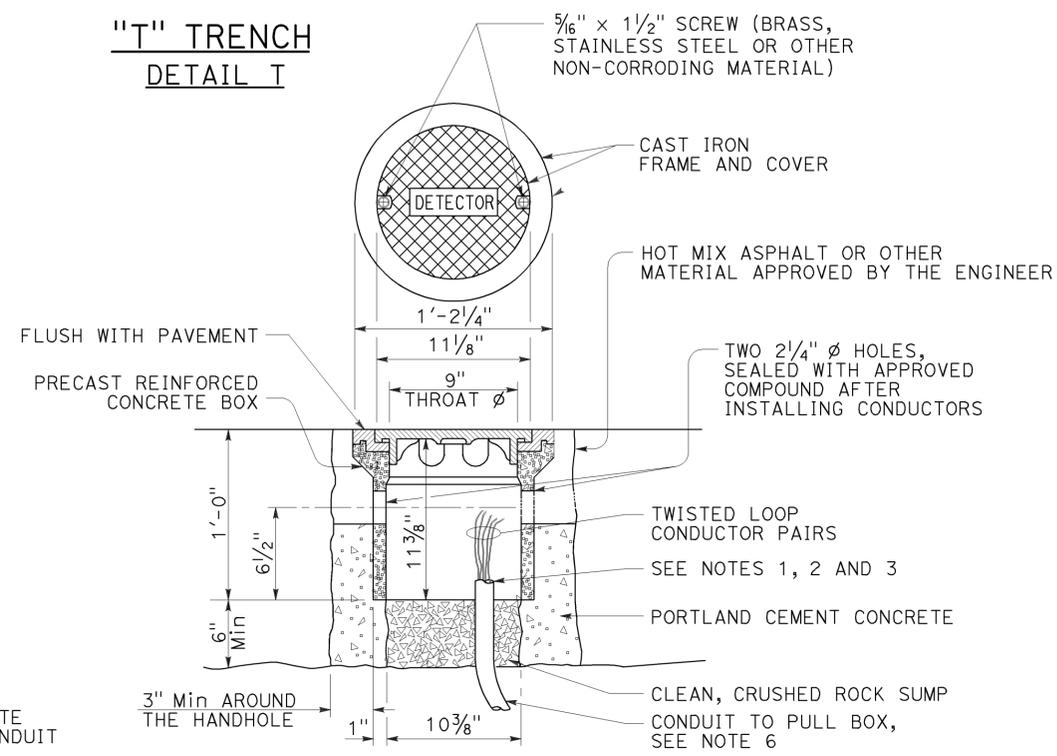


DETECTOR HANDHOLE DETAIL

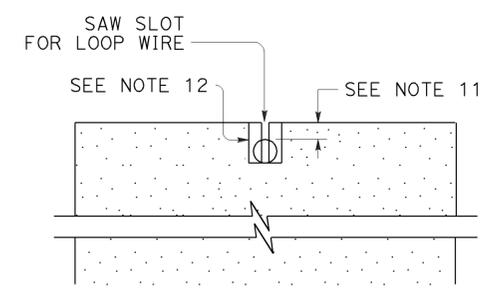


SECTION A-A

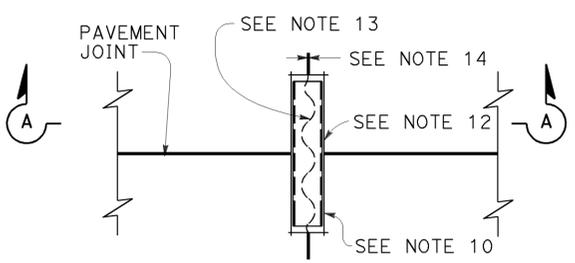


PLAN VIEW
TYPICAL LOOP LEAD-IN DETAIL
AT PAVEMENT JOINT

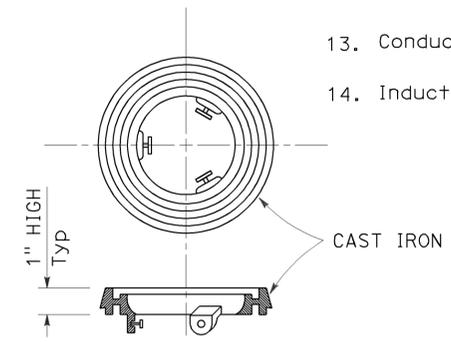

LOCKING GRADE RING

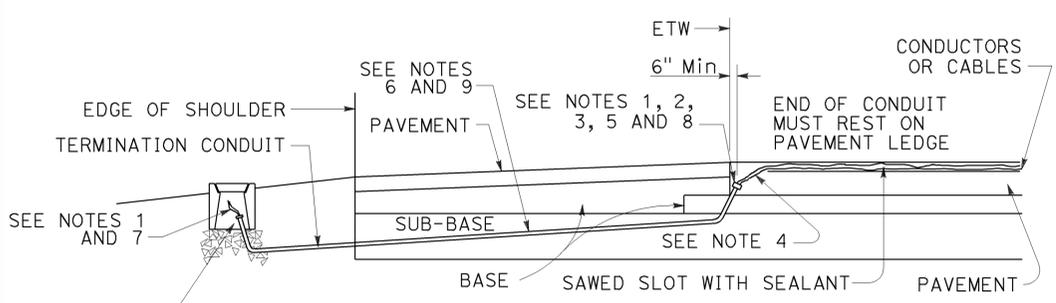

CROSS SECTION

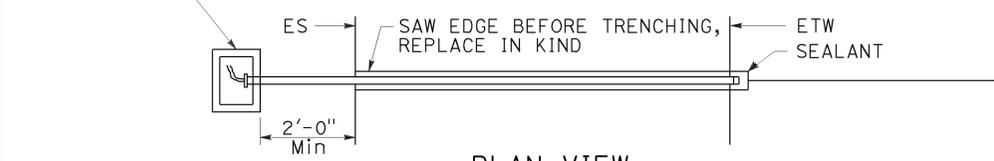

PLAN VIEW
SHOULDER TERMINATION DETAILS

NOTES:

- Bushing shall be used at end of conduit.
- Tape detector conductors or cables 3" each side of bushings.
- Install duct seal compound to each end of termination conduit before installing sealant.
- Round all sharp edges where detector conductors or cables have to pass.
- End of conduit shall be 3/8" below roadway surface.
- Conduit size Loop conductors
 1"C minimum 1 to 2 pairs
 1 1/2"C minimum 3 to 4 pairs
 2"C minimum 5 or more pairs
- Splice detector conductors or cables to detector lead-in-cable.
- Location of detector handhole when shown on plans.
- When the shoulder and traveled way are paved with the same material and there is no joint between them, the conduit shall extend only 2'-0" into the shoulder pavement.
- 3/4"C, Type 3 conduit 6" long minimum, plug both ends with duct compound to keep out sealant.
- 1/2" Minimum between top of conduit and pavement surface.
- Sawcut shall not exceed 1" in width and 1/8" longer than conduit to be installed.
- Conductors with 1/2" minimum slack inside conduit.
- Inductive loop detector saw slot.

STATE OF CALIFORNIA
DEPARTMENT OF TRANSPORTATION
ELECTRICAL SYSTEMS
(CURB TERMINATION
AND HANDHOLE)
NO SCALE

RSP ES-5D DATED JULY 19, 2013 SUPERSEDES STANDARD PLAN ES-5D
DATED MAY 20, 2011 - PAGE 451 OF THE STANDARD PLANS BOOK DATED 2010.

REVISED STANDARD PLAN RSP ES-5D

2010 REVISED STANDARD PLAN RSP ES-5D


DIST	COUNTY	ROUTE	POST MILES TOTAL PROJECT	SHEET NO.	TOTAL SHEETS
03	ED, Sac, Yol	49, 50, 80	Var	25	25

Theresa Gabriel
 REGISTERED ELECTRICAL ENGINEER
 July 19, 2013
 PLANS APPROVAL DATE

REGISTERED PROFESSIONAL ENGINEER
 Theresa Aziz Gabriel
 No. E15129
 Exp. 6-30-14
 ELECTRICAL
 STATE OF CALIFORNIA

THE STATE OF CALIFORNIA OR ITS OFFICERS OR AGENTS SHALL NOT BE RESPONSIBLE FOR THE ACCURACY OR COMPLETENESS OF SCANNED COPIES OF THIS PLAN SHEET.

TO ACCOMPANY PLANS DATED 1-27-15

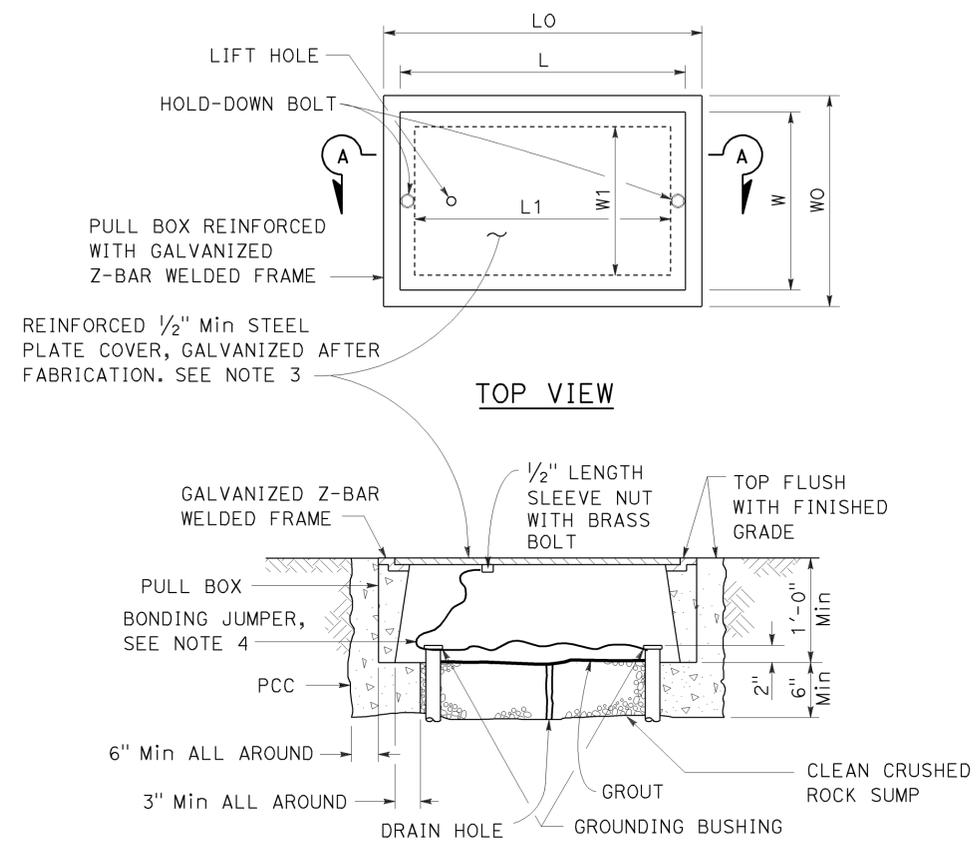

SECTION A-A
 No. 3 1/2(T), No. 5(T) AND
 No. 6(T) TRAFFIC PULL BOX

NOTES:

- Traffic pull box shall be provided with steel cover and special concrete footing. Steel cover shall have embossed non-skid pattern.
- Steel reinforcing shall be as regularly used in the standard products of the respective manufacturer.
- Pull box covers shall be marked as follows: "SERVICE" Service circuits between service point and service disconnect; "SPRINKLER-CONTROL" Sprinkler control circuits, 50 V or less; "CALTRANS" On all pull boxes, except pull boxes marked "SPRINKLER-CONTROL"; and "TELEPHONE" Telephone service.
 - No. 3 1/2(T) pull box.
 - "SIGNAL" - Traffic signal circuits with or without lighting or sign lighting circuits.
 - "LIGHTING" - Lighting or sign lighting circuits where voltage is under 600 V.
 - No. 5(T) or 6(T) pull box.
 - "TRAFFIC SIGNAL" - Traffic signal circuits with or without lighting or sign lighting circuits.
 - "LIGHTING" - Lighting or sign lighting circuits where voltage is under 600 V.
 - "LIGHTING-HIGH VOLTAGE" - Lighting or sign lighting circuits where voltage is above 600 V.
 - "IRRIGATION" - Circuits to irrigation controller 120 V or more.
 - "RAMP METER" - Ramp meter circuits.
 - "COUNT STATION" - Count or speed monitor circuits.
 - "COMMUNICATION" - Communication circuits.
 - "TOS COMMUNICATIONS" - TOS communications line.
 - "TOS POWER" - TOS power.
 - "TDC POWER" - Telephone demarcation cabinet power.
 - "CCTV" - Closed circuit television circuits.
 - "TMS" - Traffic monitoring station circuits.
 - "CMS" - Changeable message sign circuits.
 - "HAR" - Highway advisory radio circuits.
 - "BOOSTER PUMP" - Booster pump circuit.
- Bonding jumper for metal covers shall be 3' long, minimum.
- The nominal dimensions of the opening in which the cover sets shall be the same as the cover dimensions except the length and width dimensions shall be 1/8" greater.
- Covers and boxes shall be interchangeable with California standard male and female gages. When interchanged with a standard male or female gage, the top surfaces shall be flush within 1/8".

PULL BOX	PULL BOX						COVER				
	MINIMUM * THICKNESS	MINIMUM DEPTH BOX AND EXTENSION	W0	L0	L1	W1	L **	W **	R	EDGE THICKNESS	EDGE TAPER
No. 3 1/2(T)	1 1/2"	1'-0"	1'-5"± 1"	1'-8 3/8"±	1'-2 1/2"±	10 5/8"± 1"	1'-8"±	1'-1 3/4"±	0"	1/2"	NONE
No. 5(T)	1 3/4"	1'-0"	1'-11 1/2"± 1"	2'-5 1/2"±	1'-7"±	1'-1"± 1"	2'-3"±	1'-4"±	0"	1/2"	NONE
No. 6(T)	2"	1'-0"	2'-6"± 1"	2'-11 1/2"±	1'-11 1/2"±	1'-5"± 1"	2'-9"±	1'-8"±	0"	1/2"	NONE

* EXCLUDING CONDUIT WEB ** TOP DIMENSION

STATE OF CALIFORNIA
 DEPARTMENT OF TRANSPORTATION
**ELECTRICAL SYSTEMS
 (TRAFFIC PULL BOX)**
 NO SCALE

RSP ES-8B DATED JULY 19, 2013 SUPERSEDES RSP ES-8B DATED JANUARY 20, 2012 THAT SUPPLEMENTS THE STANDARD PLANS BOOK DATED 2010.

REVISED STANDARD PLAN RSP ES-8B

2010 REVISED STANDARD PLAN RSP ES-8B